



APPENDIX “A”
Preliminary Plan and Profile Drawings

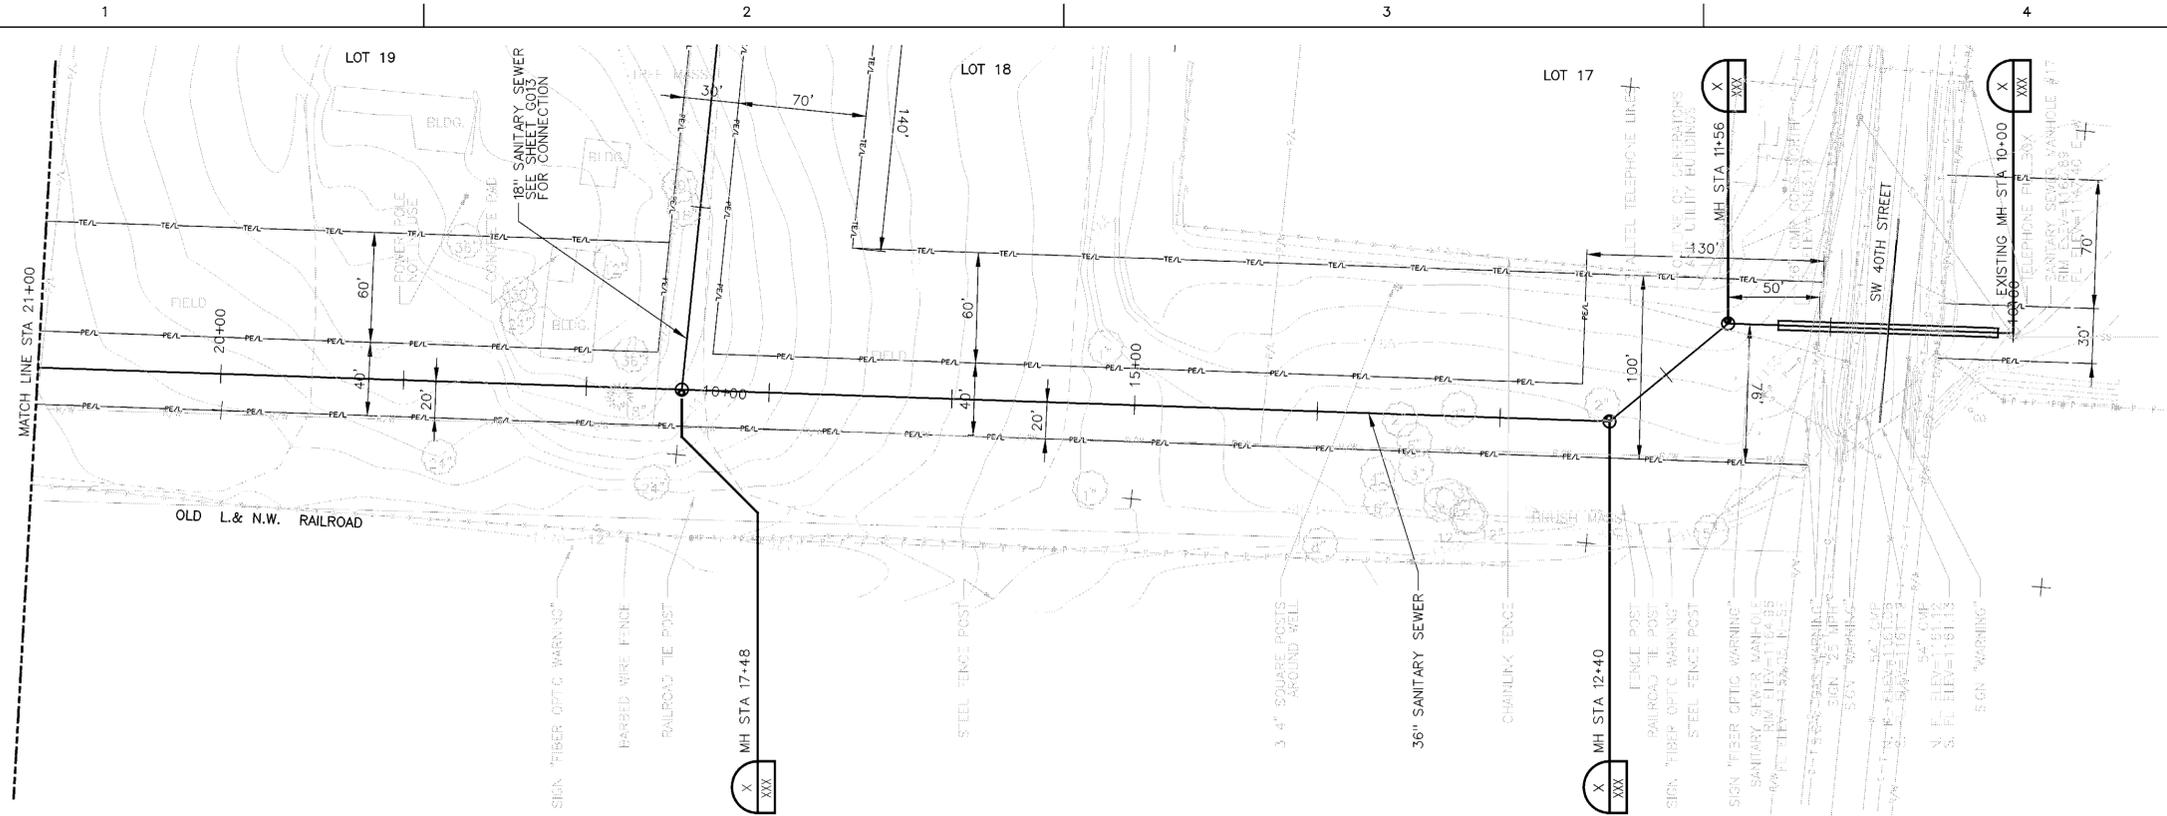

HORIZONTAL SCALE: 1"=50'
 VERTICAL SCALE: 1"=10'
 CONTOUR INTERVAL: 1'-0"

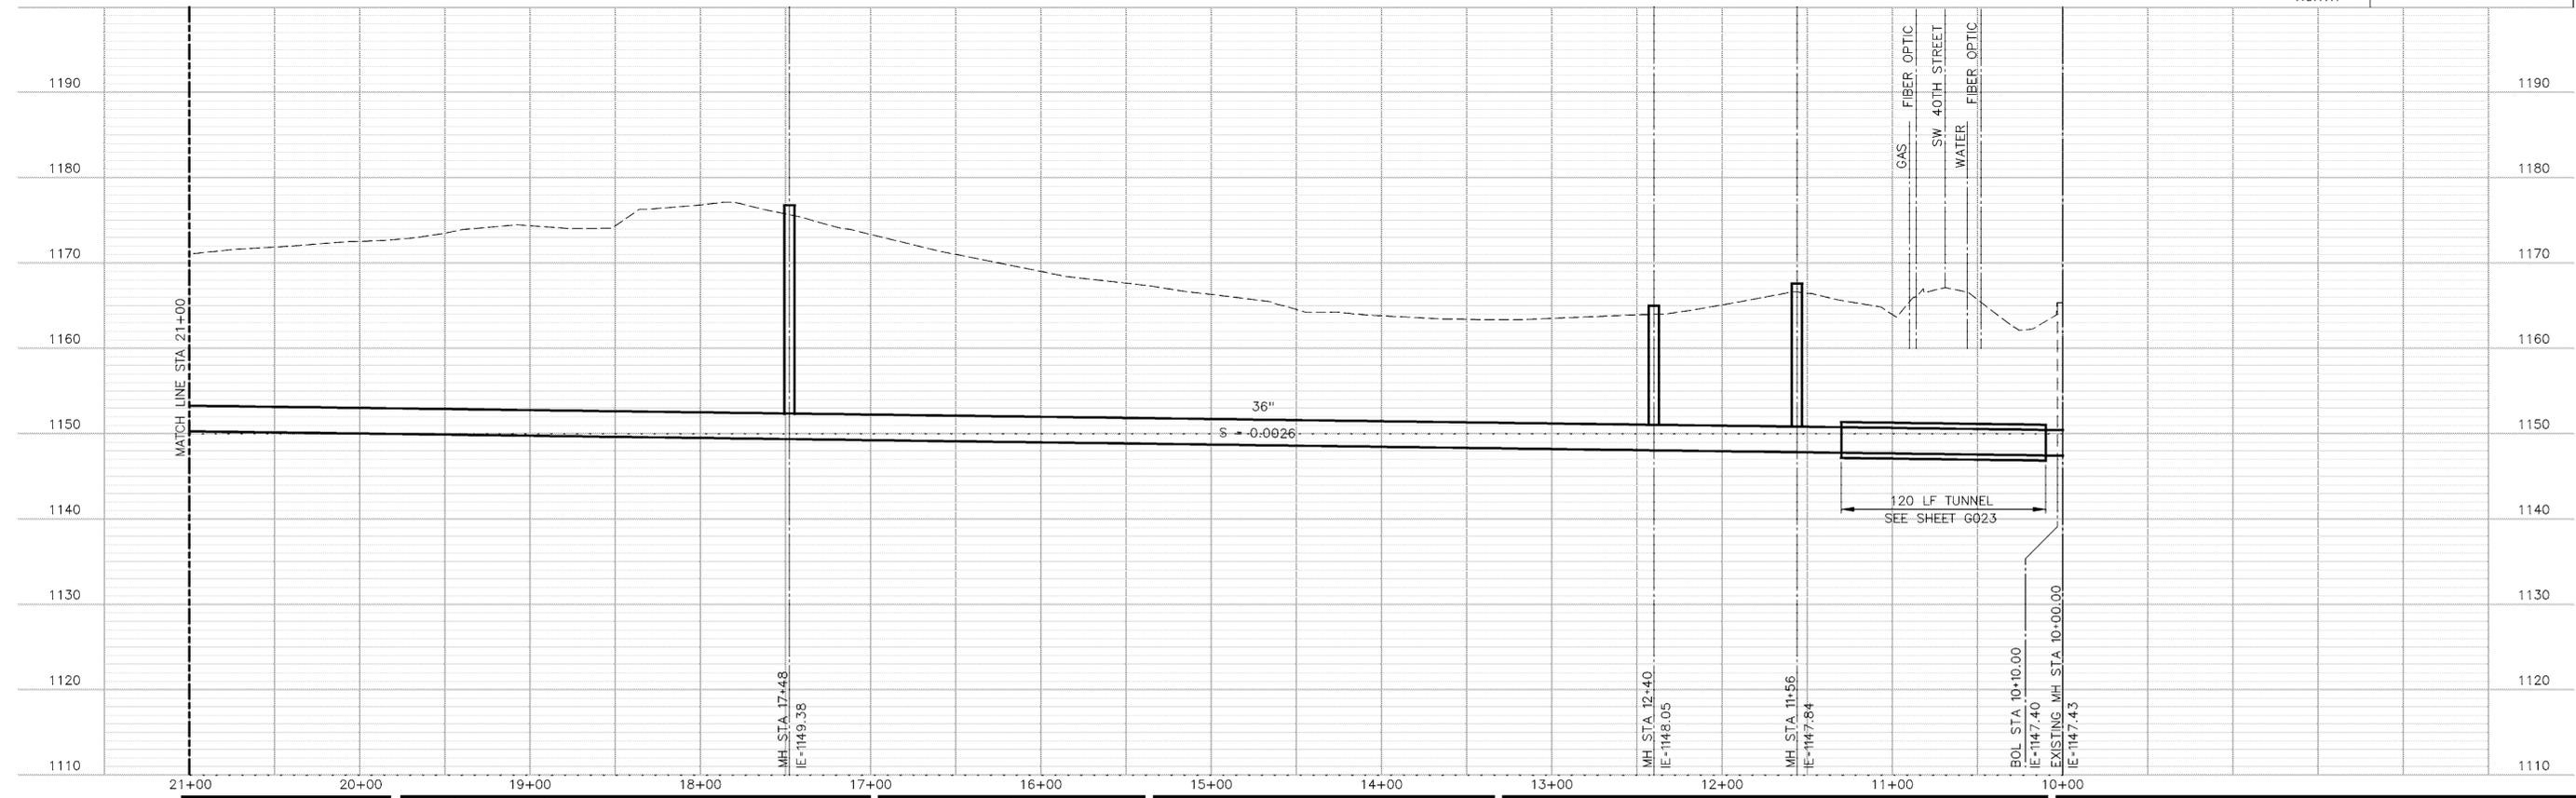

C:\WINDOWS\LINCOLN\O_STTRUNK_SEWER\00G007.DGN
 10/26/2004 9:07:36 AM JRay



ISSUE	DATE	DESCRIPTION
01	10-27-04	30% REVIEW DOCUMENTS

PROJECT MANAGER	KENT PRIOR
CIVIL	SCOTT AURIT
STRUCTURAL	
ARCHITECTURAL	
PROCESS	
MECHANICAL	
ELECTRICAL	
INSTRUMENTATION	
PROJECT NUMBER	12733

PRELIMINARY
 NOT FOR
 CONSTRUCTION
 OR
 RECORDING




**West 'O' Street
 Trunk Sewer Extension
 Lincoln, Nebraska
 2005**


**TRUNK SEWER
 PLAN AND PROFILE
 STA 10+00 TO STA 21+00**

FILENAME: 00G007.DGN
 SCALE: AS SHOWN

SHEET
G007

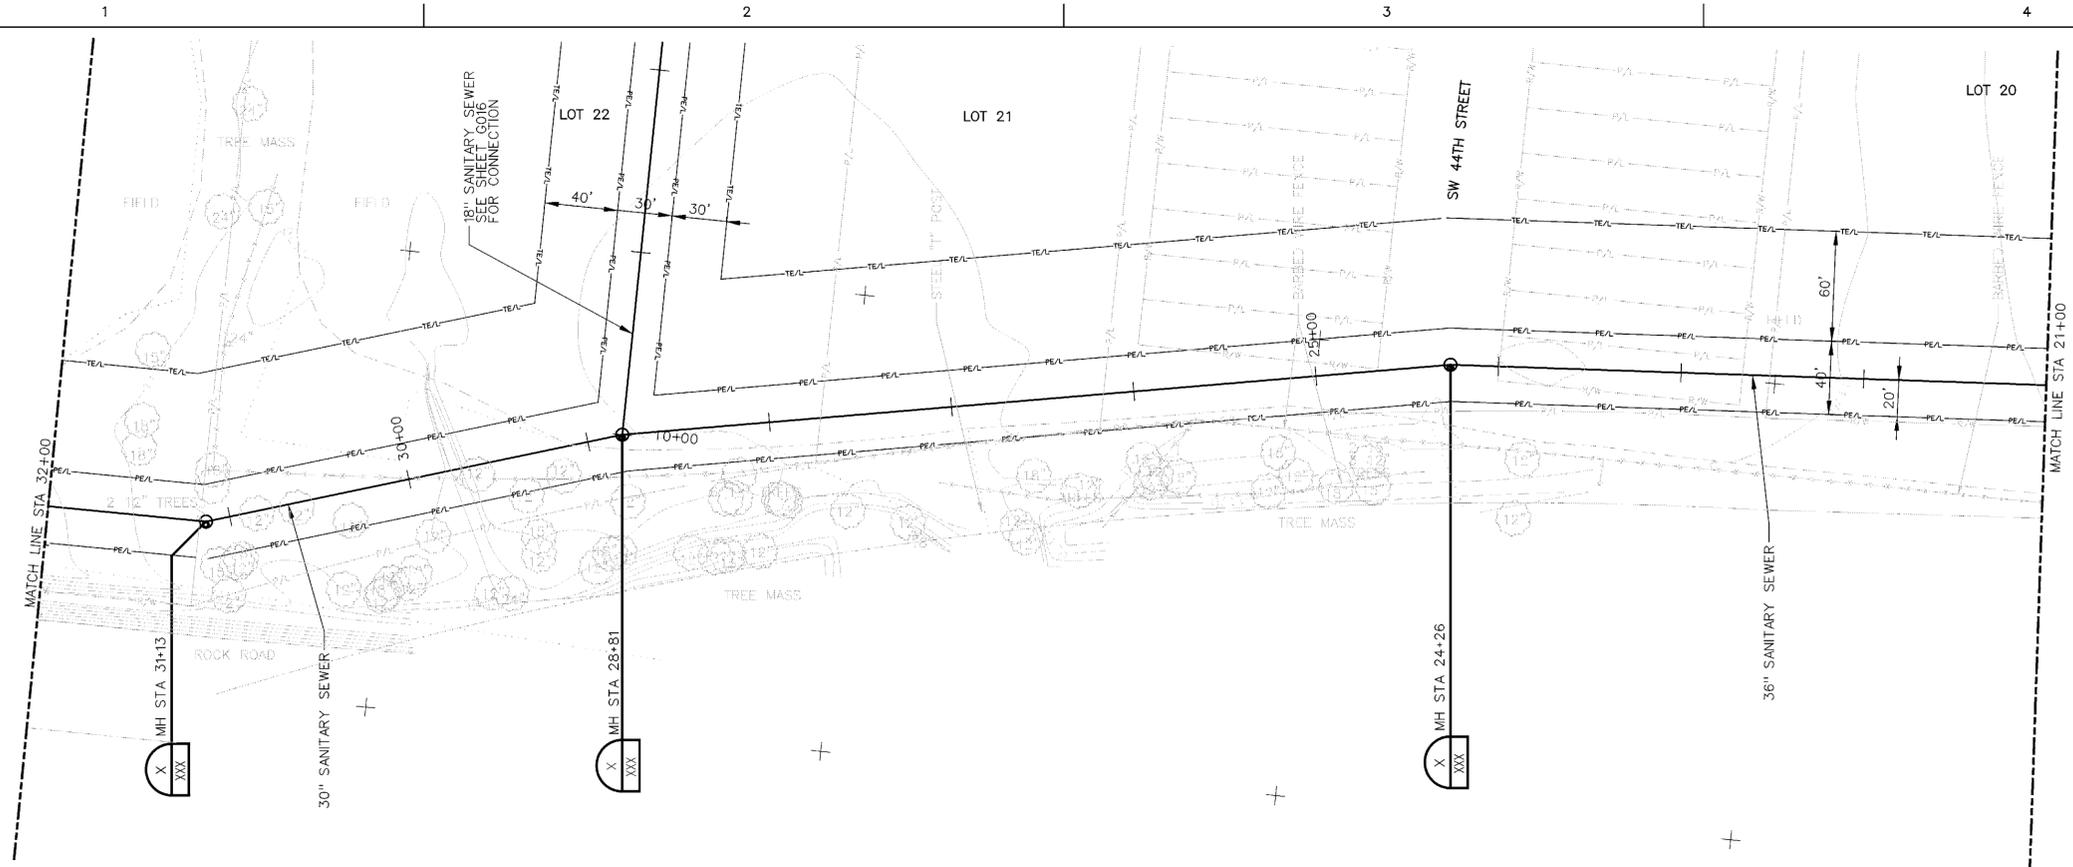

HORIZONTAL SCALE: 1"=50'
 VERTICAL SCALE: 1"=10'
 CONTOUR INTERVAL: 1'-0"

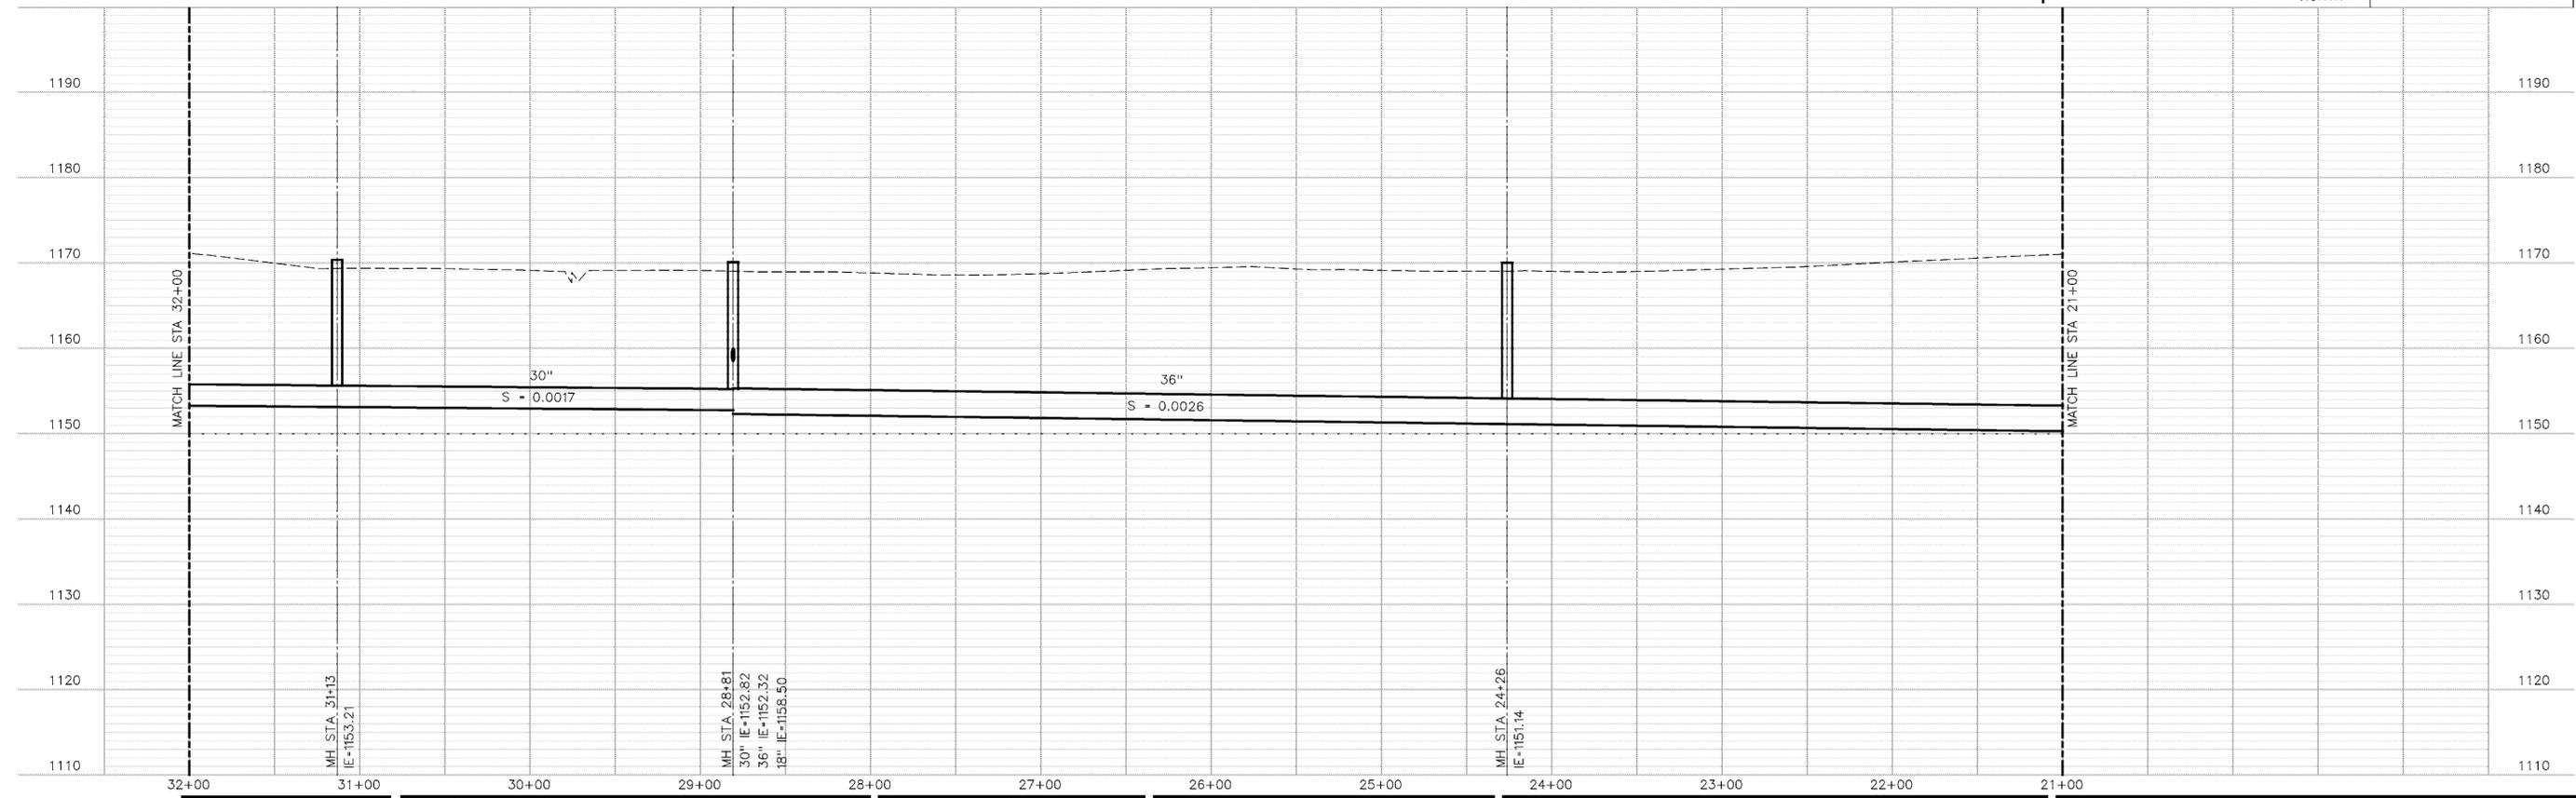

C:\WINDOWS\LINCOLN\O_STTRUNK_SEWER\00G008.DGN
 10/26/2004 9:08:11 AM JRaye



ISSUE	DATE	DESCRIPTION
01	10-27-04	30% REVIEW DOCUMENTS

PROJECT MANAGER	KENT PRIOR
CIVIL	SCOTT AURIT
STRUCTURAL	
ARCHITECTURAL	
PROCESS	
MECHANICAL	
ELECTRICAL	
INSTRUMENTATION	
PROJECT NUMBER	12733

PRELIMINARY
 NOT FOR
 CONSTRUCTION
 OR
 RECORDING




**West 'O' Street
 Trunk Sewer Extension
 Lincoln, Nebraska
 2005**


**TRUNK SEWER
 PLAN AND PROFILE
 STA 21+00 TO STA 32+00**

0 1" 2"

FILENAME	00G008.DGN	SHEET	G008
SCALE	AS SHOWN		

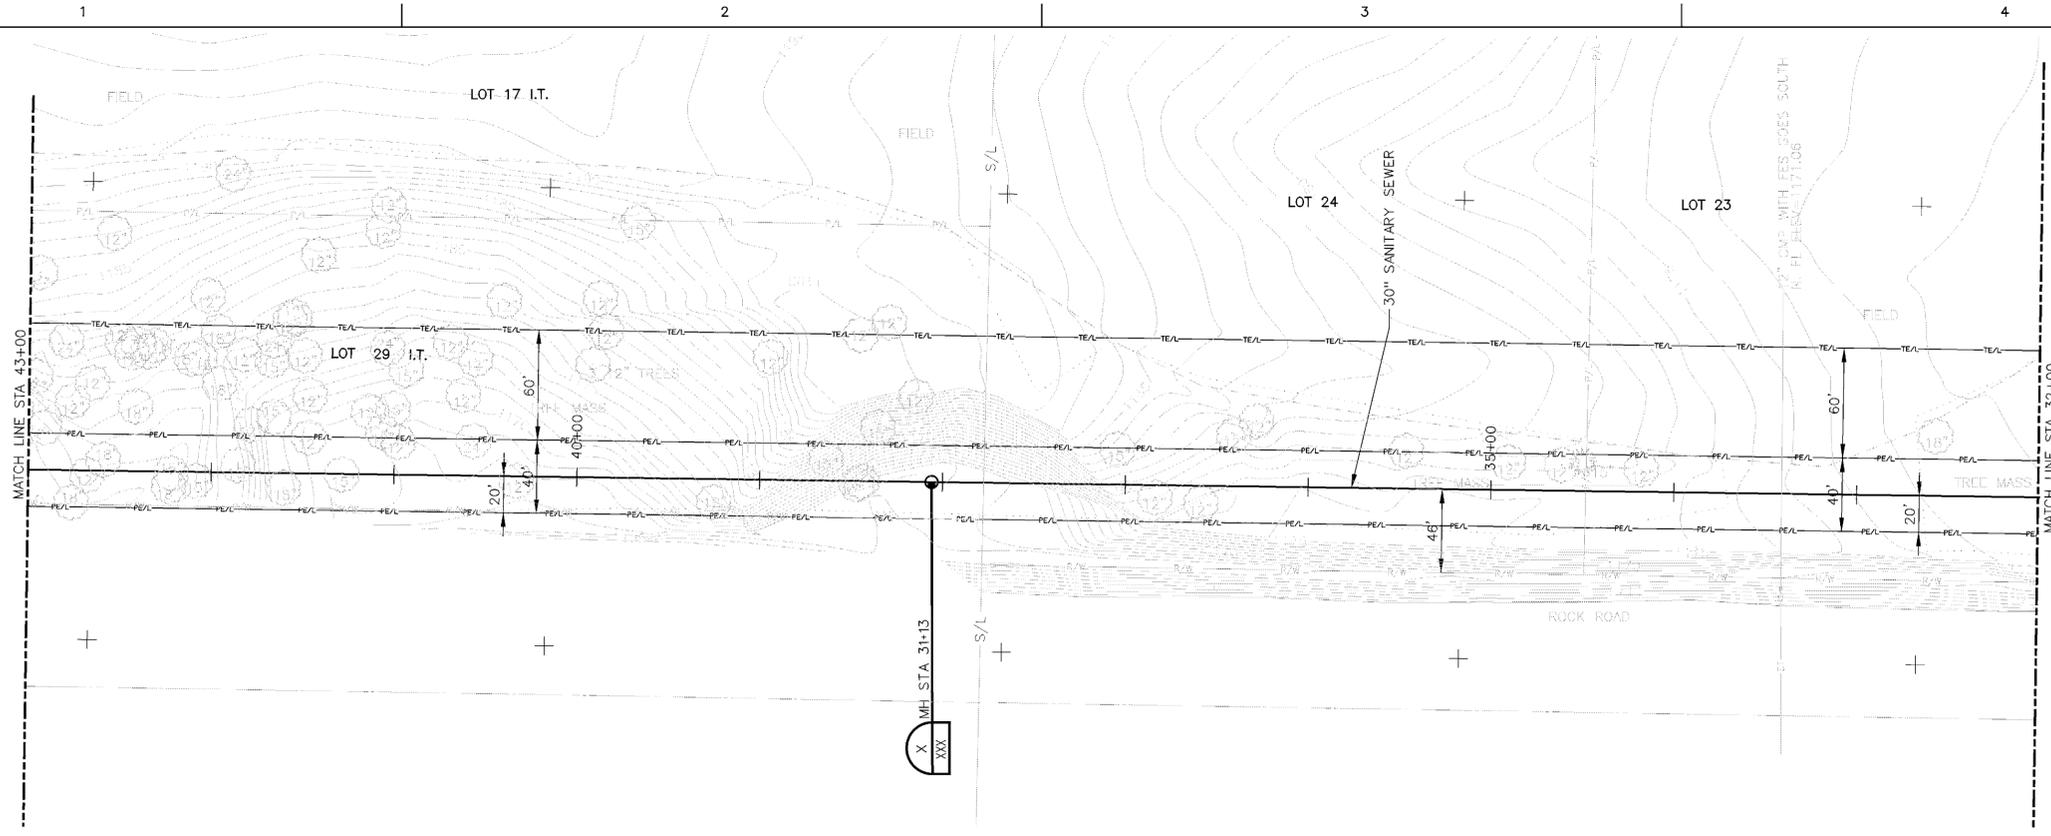

HORIZONTAL SCALE: 1"=50'
 VERTICAL SCALE: 1"=10'
 CONTOUR INTERVAL: 1'-0"

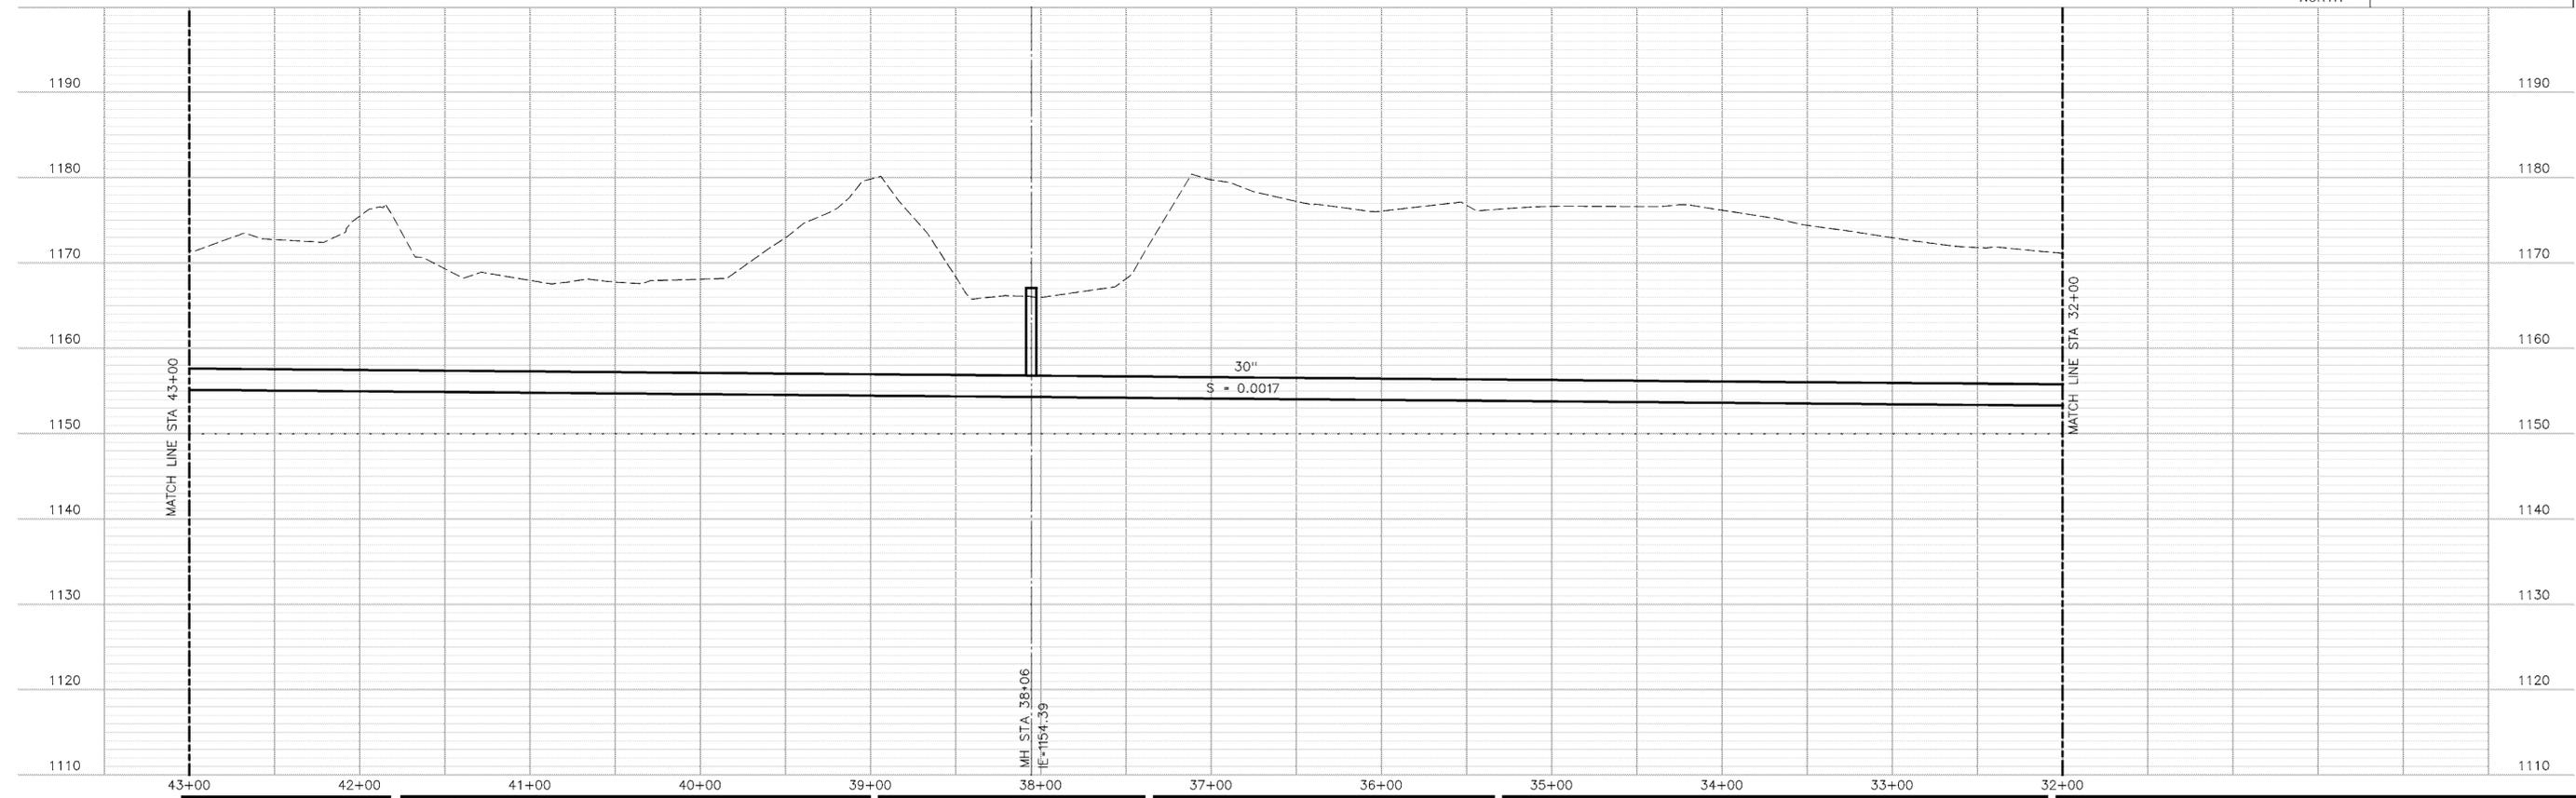

C:\WINDOWS\LINCOLN\O_STTRUNK_SEWER\00G009.DGN
 10/26/2004 9:08:35 AM JRayner



ISSUE	DATE	DESCRIPTION
01	10-27-04	30% REVIEW DOCUMENTS


PROJECT MANAGER	KENT PRIOR
CIVIL	SCOTT AURIT
STRUCTURAL	
ARCHITECTURAL	
PROCESS	
MECHANICAL	
ELECTRICAL	
INSTRUMENTATION	
PROJECT NUMBER	12733

PRELIMINARY
 NOT FOR
 CONSTRUCTION
 OR
 RECORDING




**West 'O' Street
 Trunk Sewer Extension
 Lincoln, Nebraska
 2005**

	TRUNK SEWER PLAN AND PROFILE STA 32+00 TO STA 43+00	SHEET G009
FILENAME: 00G009.DGN SCALE: AS SHOWN		

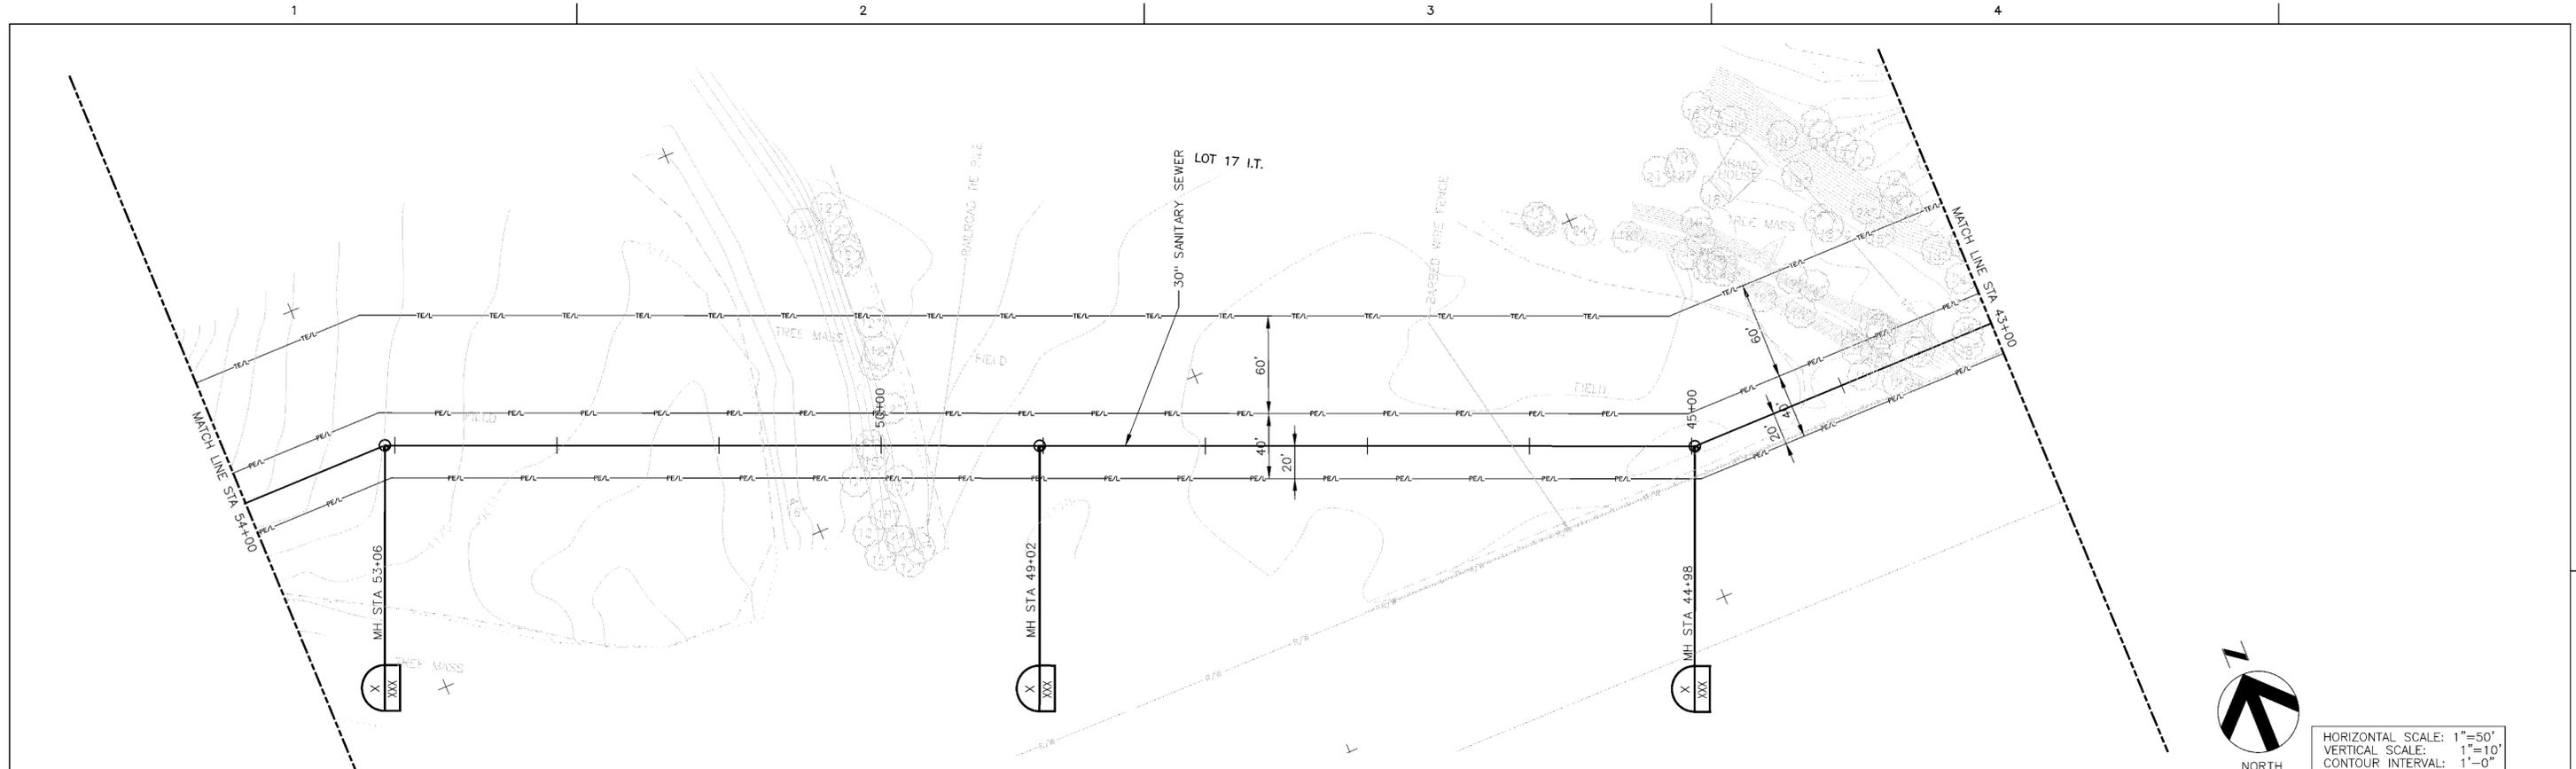

HORIZONTAL SCALE: 1"=50'
 VERTICAL SCALE: 1"=10'
 CONTOUR INTERVAL: 1'-0"

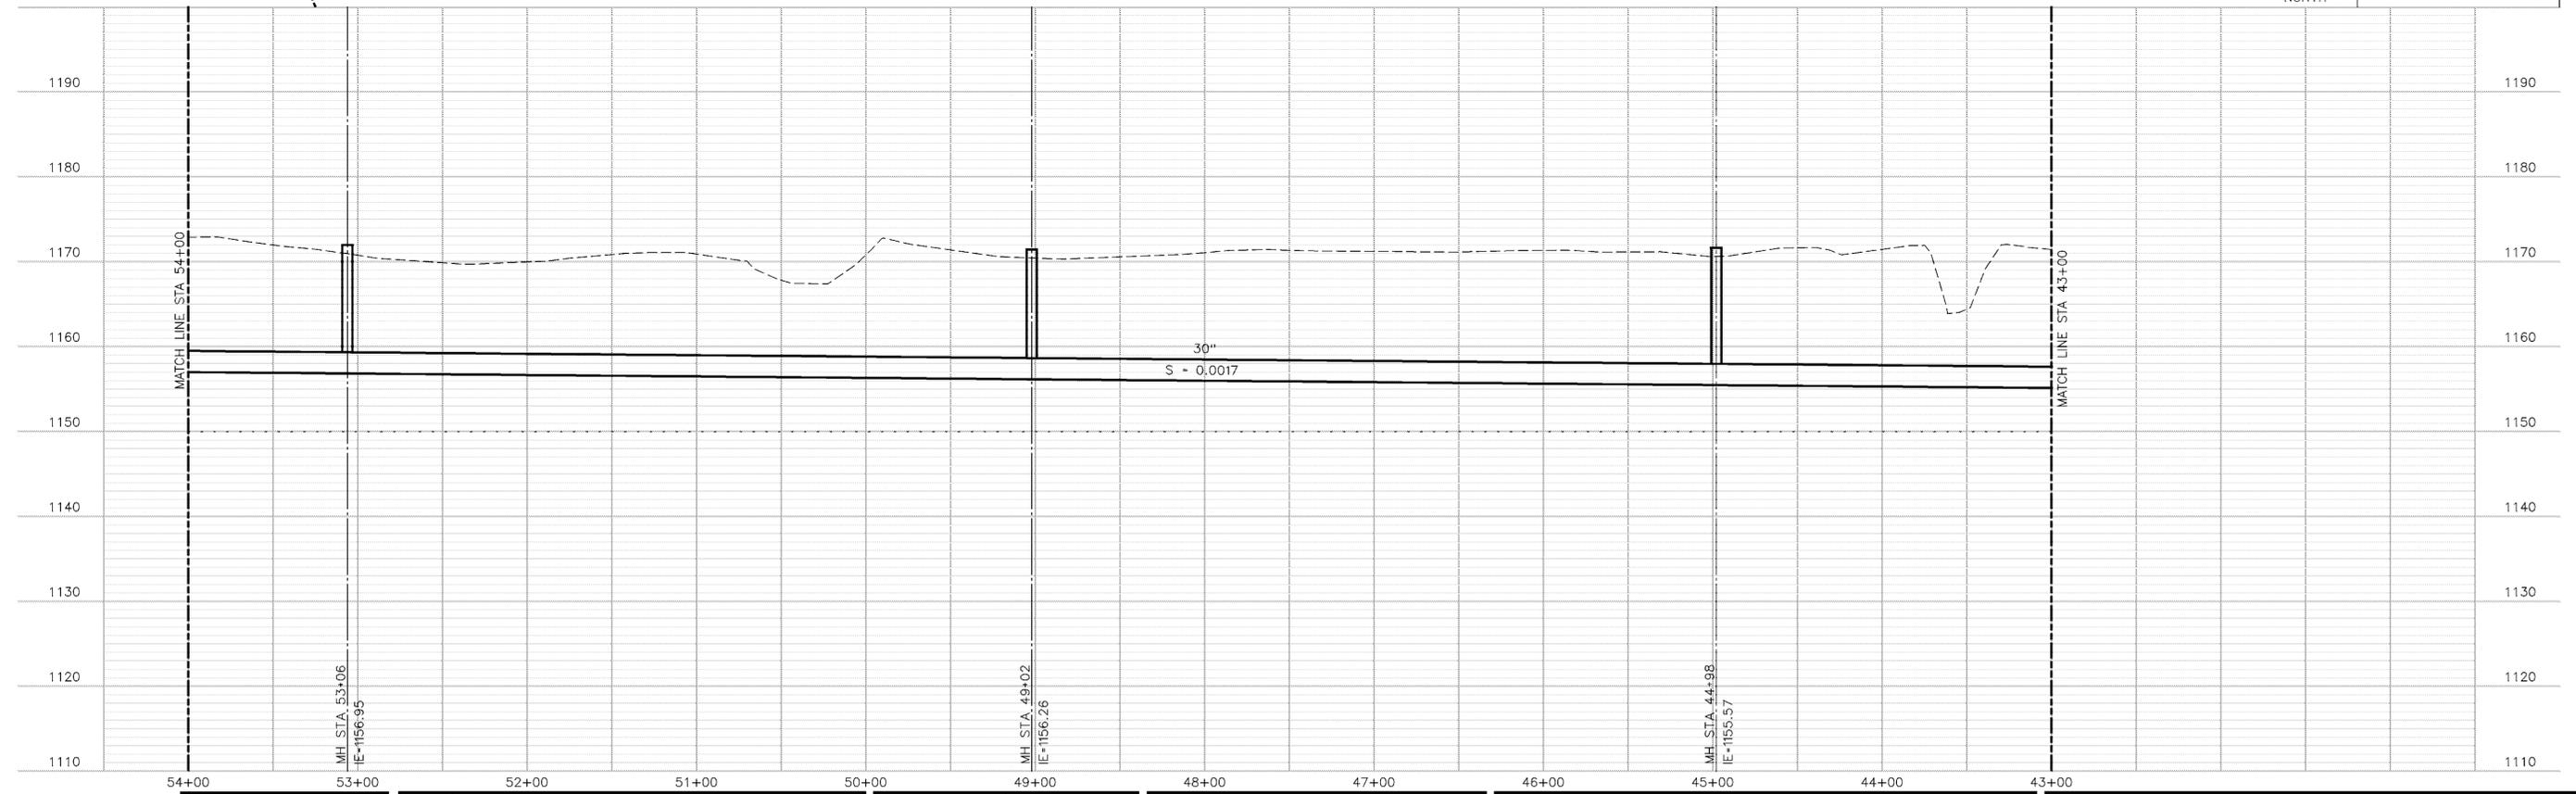

C:\WINDOWS\LINCOLN\O_STTRUNK_SEWER\00G010.DGN
 10/26/2004 9:09:05 AM J.Rayer



ISSUE	DATE	DESCRIPTION
01	10-27-04	30% REVIEW DOCUMENTS

PROJECT MANAGER	KENT PRIOR
CIVIL	SCOTT AURIT
STRUCTURAL	
ARCHITECTURAL	
PROCESS	
MECHANICAL	
ELECTRICAL	
INSTRUMENTATION	
PROJECT NUMBER	12733

PRELIMINARY
 NOT FOR
 CONSTRUCTION
 OR
 RECORDING




**West 'O' Street
 Trunk Sewer Extension
 Lincoln, Nebraska
 2005**


**TRUNK SEWER
 PLAN AND PROFILE
 STA 43+00 TO STA 54+00**

0 1" 2"

FILENAME	00G010.DGN	SHEET	G010
SCALE	AS SHOWN		

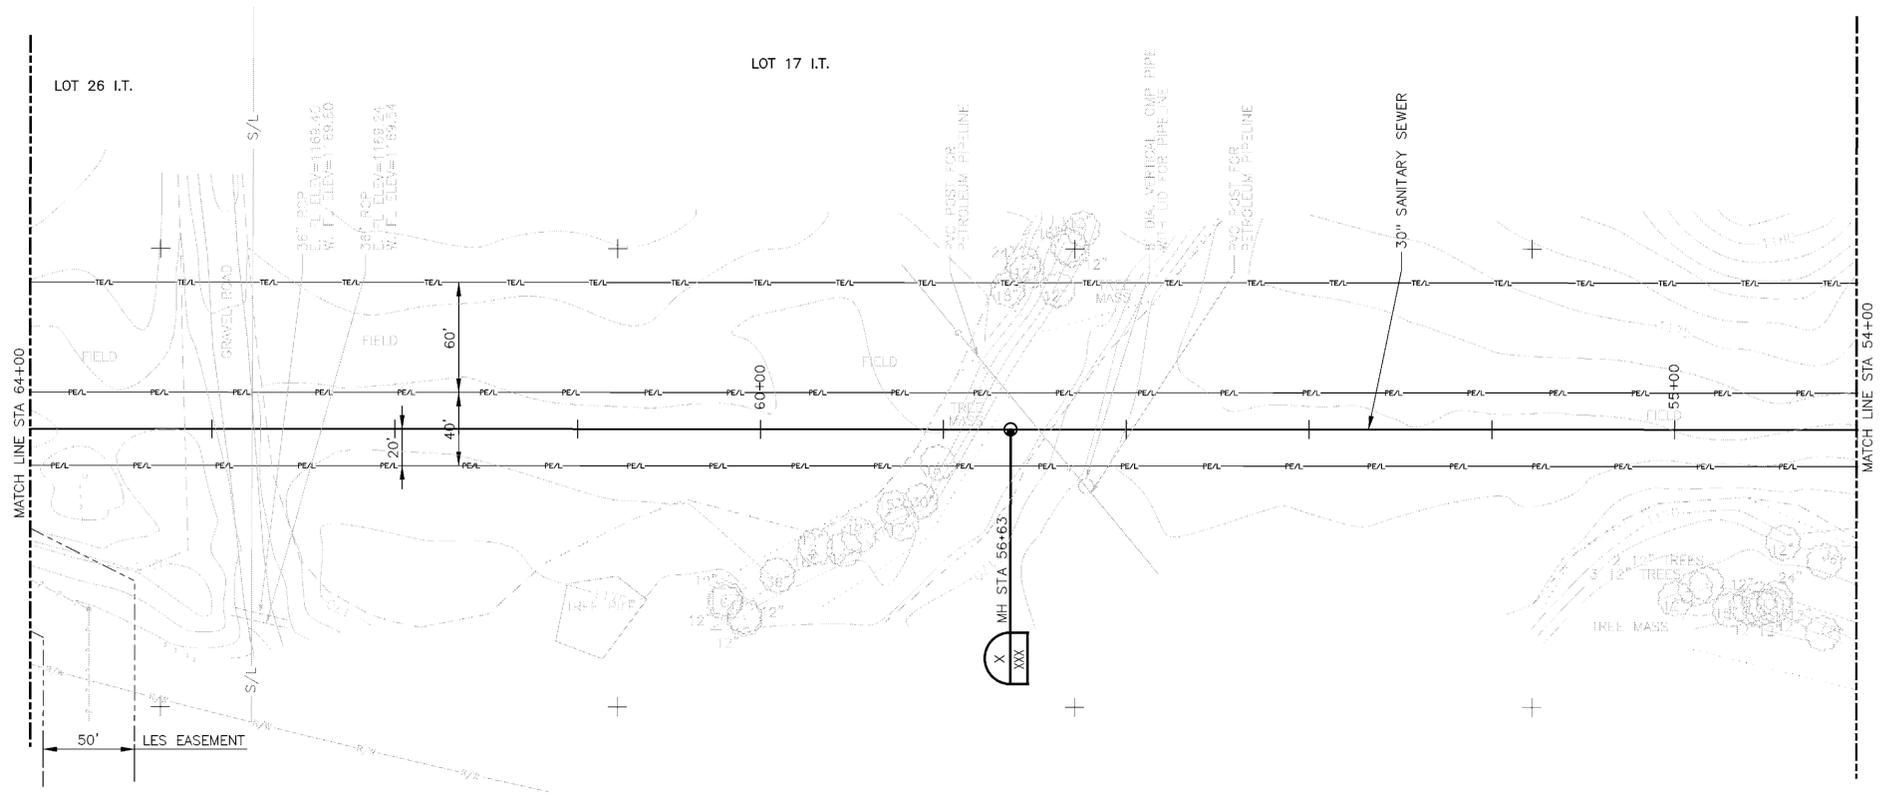

HORIZONTAL SCALE: 1"=50'
 VERTICAL SCALE: 1"=10'
 CONTOUR INTERVAL: 1'-0"

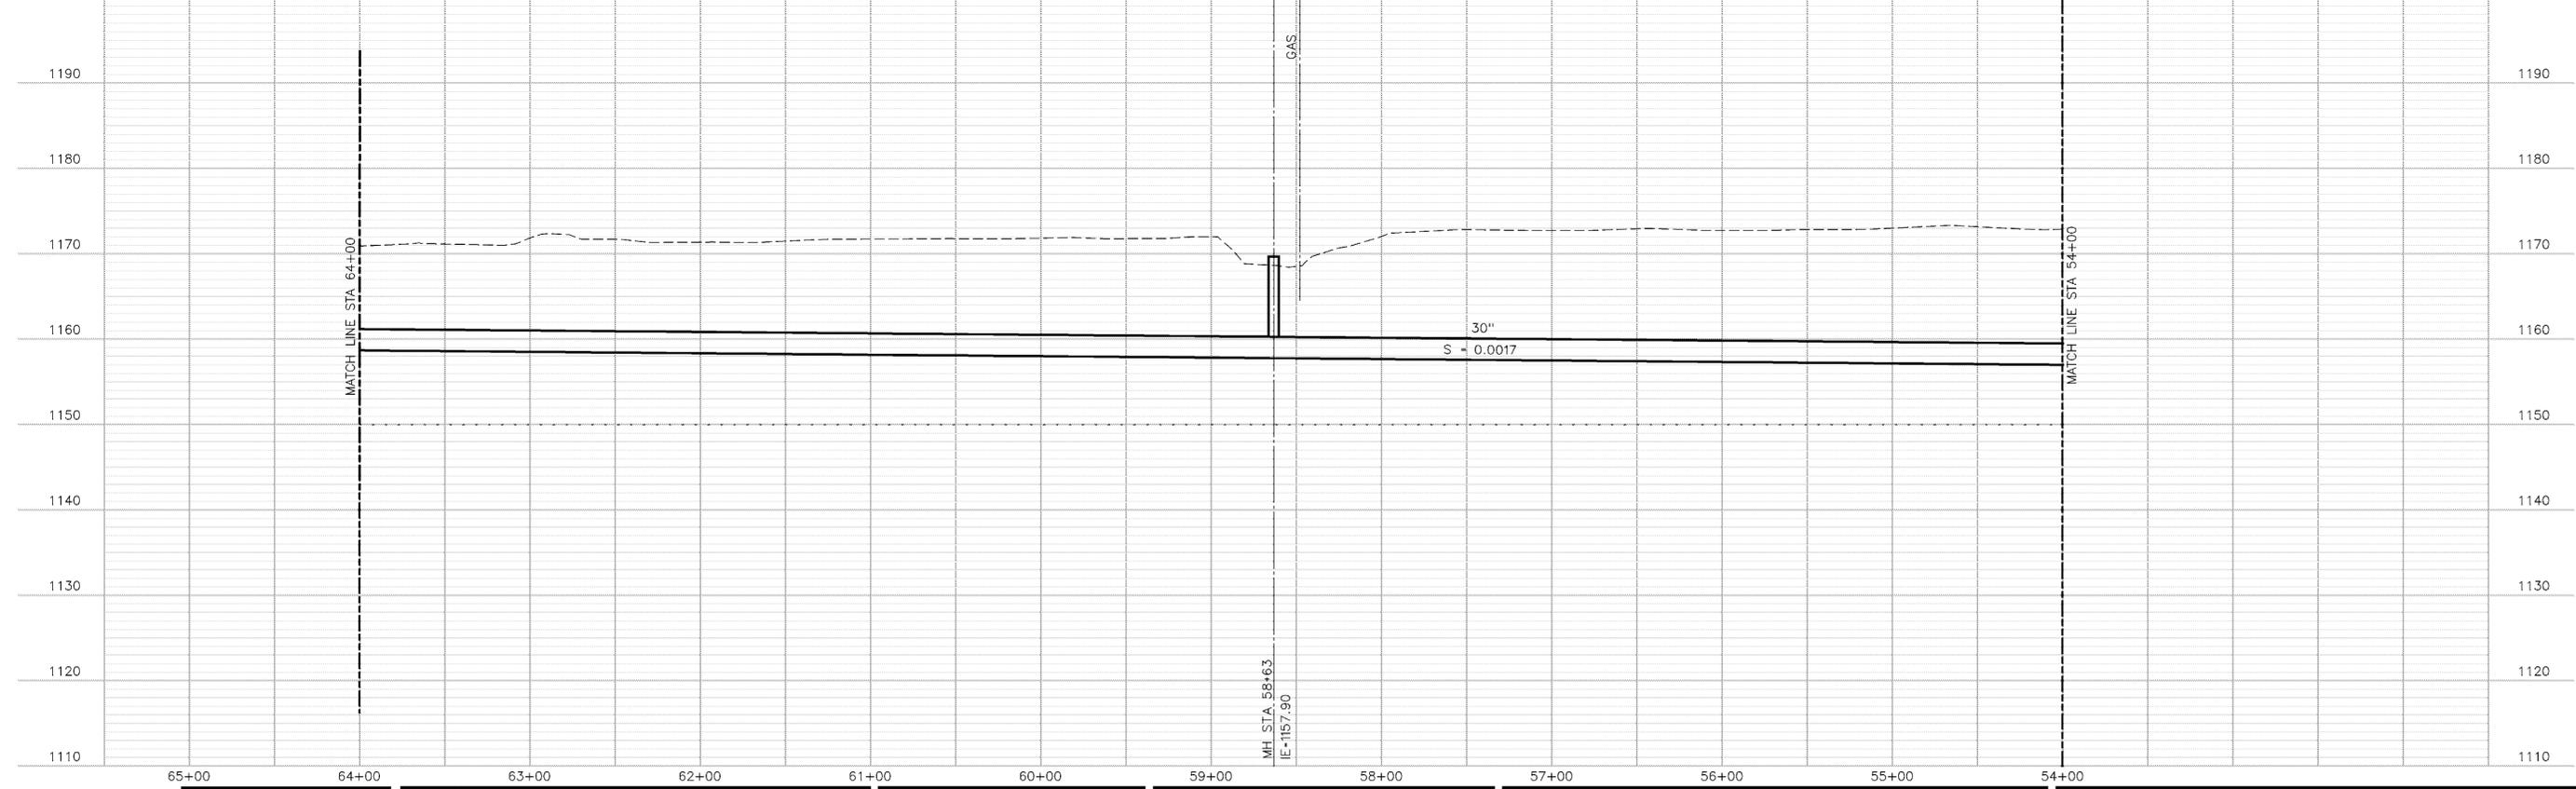

C:\WINDOWS\LINCOLN\O_STTRUNK_SEWER\006011.DGN
 10/26/2004 9:09:27 AM J.Rayer



ISSUE	DATE	DESCRIPTION
01	10-27-04	30% REVIEW DOCUMENTS

PROJECT MANAGER	KENT PRIOR
CIVIL	SCOTT AURIT
STRUCTURAL	
ARCHITECTURAL	
PROCESS	
MECHANICAL	
ELECTRICAL	
INSTRUMENTATION	
PROJECT NUMBER	12733

PRELIMINARY
 NOT FOR
 CONSTRUCTION
 OR
 RECORDING




**West 'O' Street
 Trunk Sewer Extension
 Lincoln, Nebraska
 2005**

**TRUNK SEWER
 PLAN AND PROFILE
 STA 54+00 TO STA 64+00**


0 1" 2"

FILENAME	O0G011.DGN	SHEET
SCALE	AS SHOWN	G011

C:\WINDOWS\LINCOLN\O_STTRUNK_SEWER\00G012.DGN
 10/26/2004 9:09:47 AM JRayner

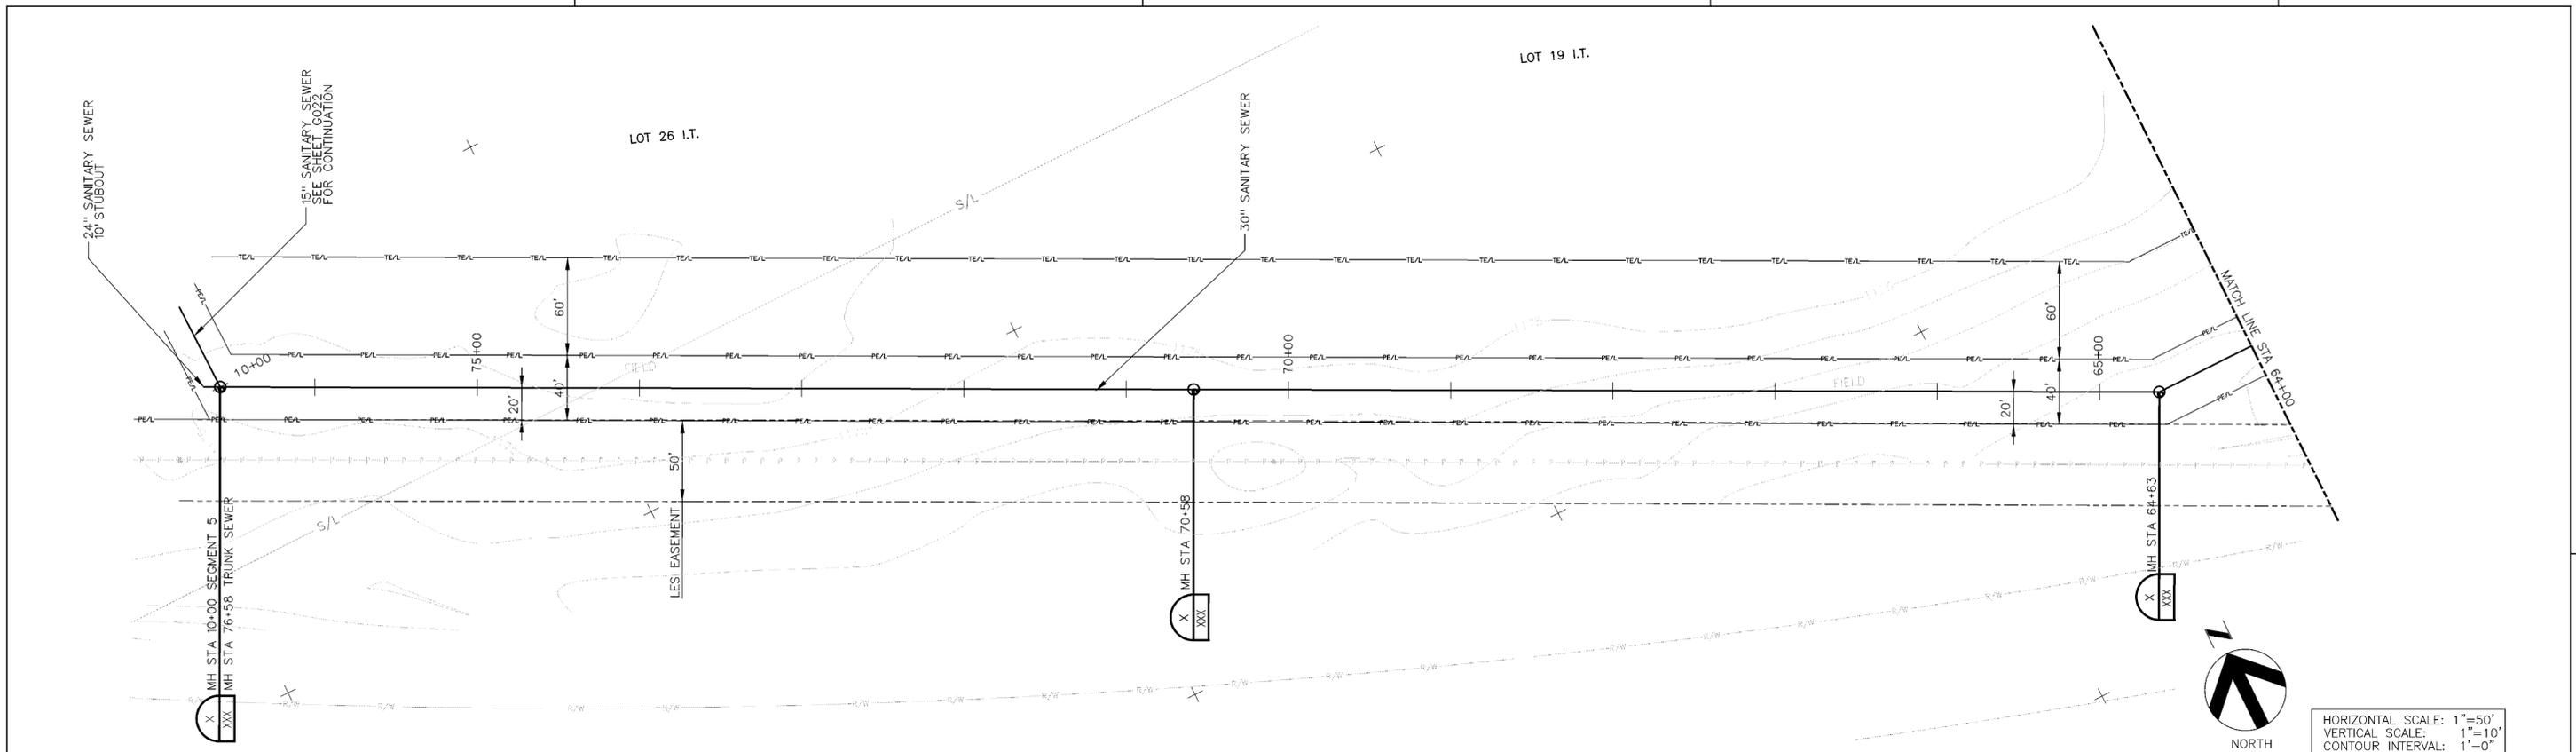

HORIZONTAL SCALE: 1"=50'
 VERTICAL SCALE: 1"=10'
 CONTOUR INTERVAL: 1'-0"

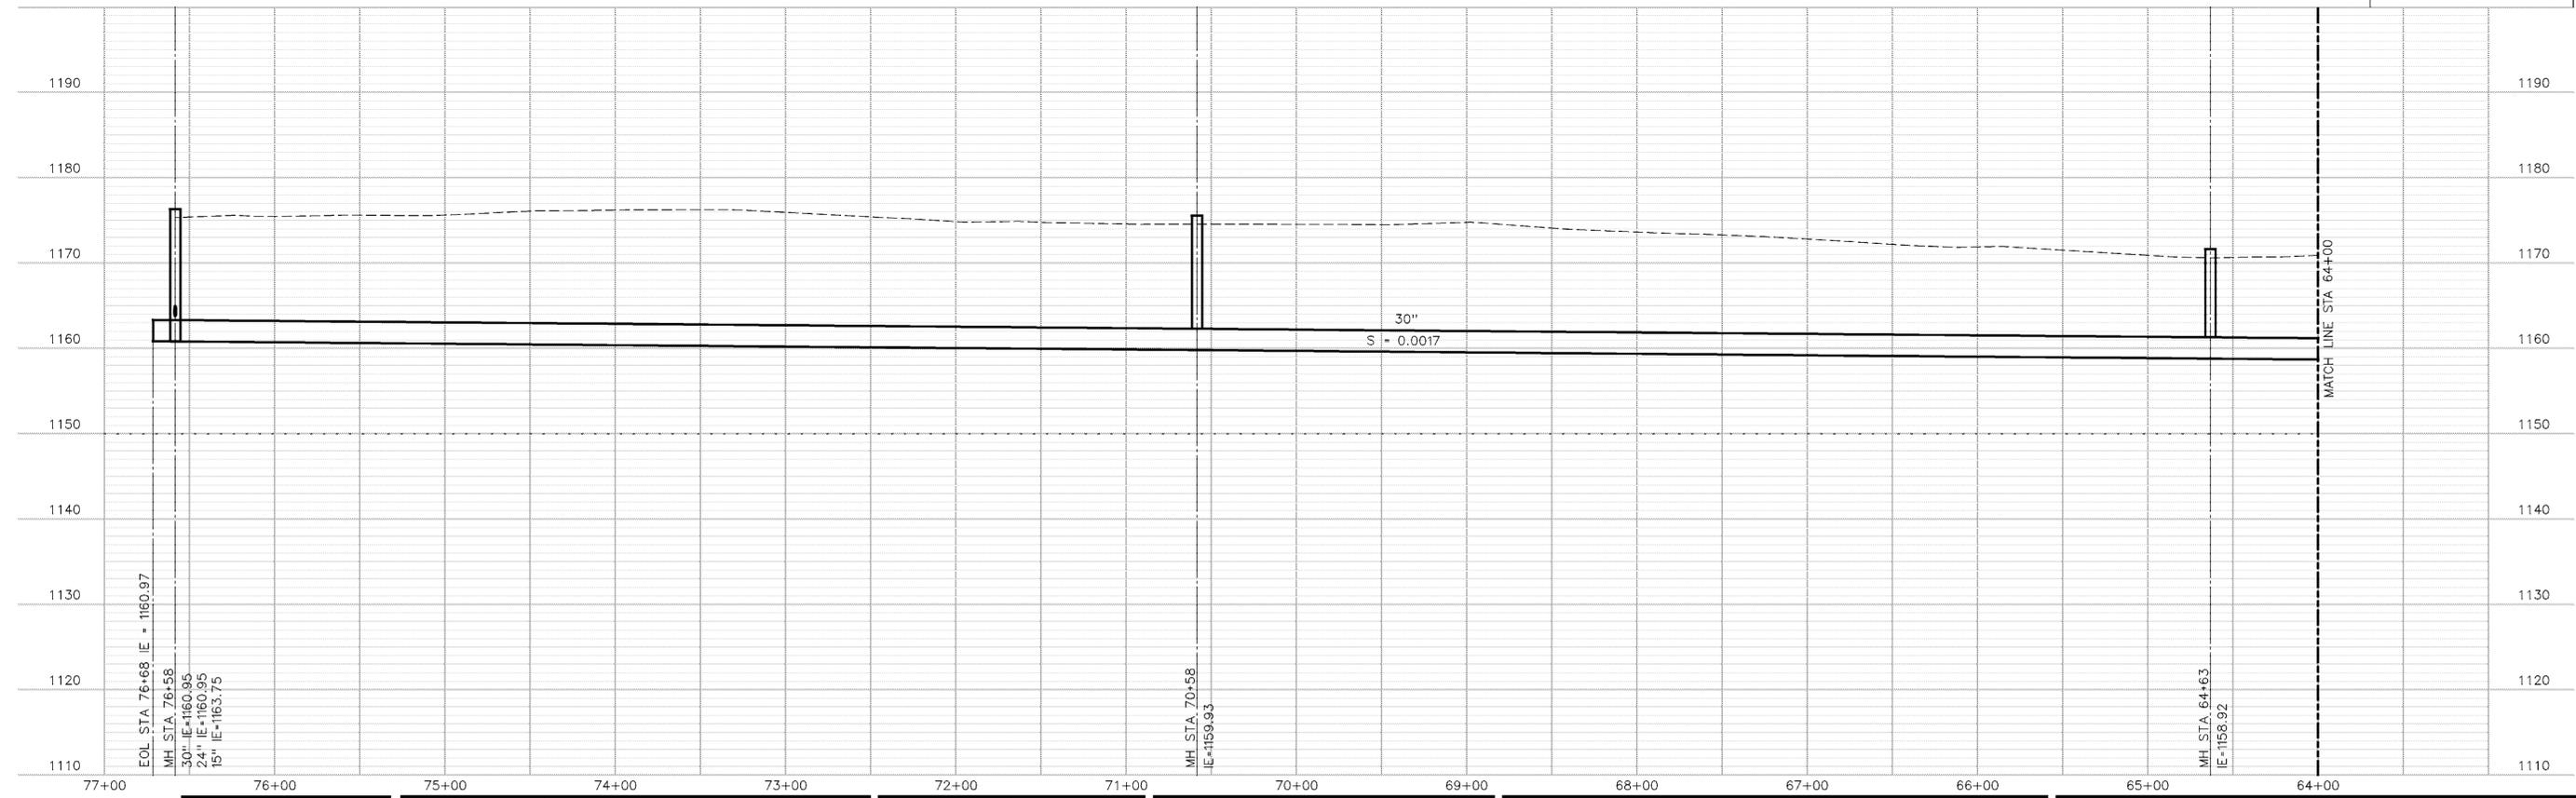

ISSUE	DATE	DESCRIPTION
01	10-27-04	30% REVIEW DOCUMENTS

PROJECT MANAGER	KENT PRIOR
CIVIL	SCOTT AURIT
STRUCTURAL	
ARCHITECTURAL	
PROCESS	
MECHANICAL	
ELECTRICAL	
INSTRUMENTATION	
PROJECT NUMBER	12733

PRELIMINARY
 NOT FOR
 CONSTRUCTION
 OR
 RECORDING




**West 'O' Street
 Trunk Sewer Extension
 Lincoln, Nebraska
 2005**

**TRUNK SEWER
 PLAN AND PROFILE
 STA 64+00 TO STA 76+58**


0 1" 2"

FILENAME	00G012.DGN	SHEET	G012
SCALE	AS SHOWN		

MATCH LINE STA 19+00
15
14

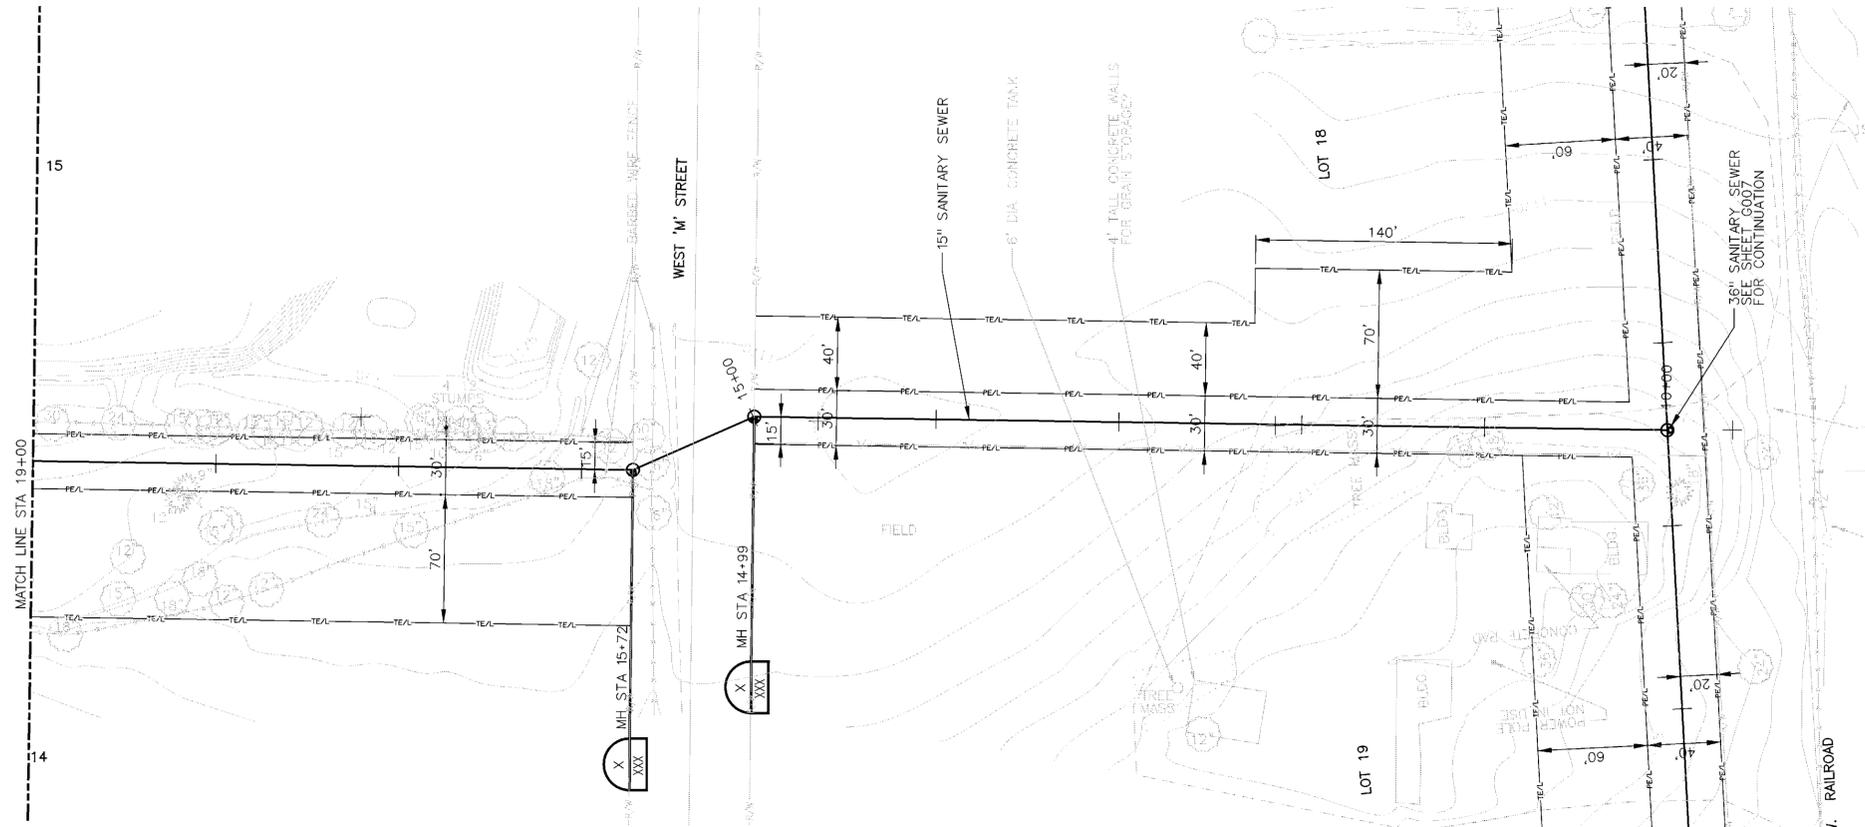

HORIZONTAL SCALE: 1"=50'
VERTICAL SCALE: 1"=10'
CONTOUR INTERVAL: 1'-0"

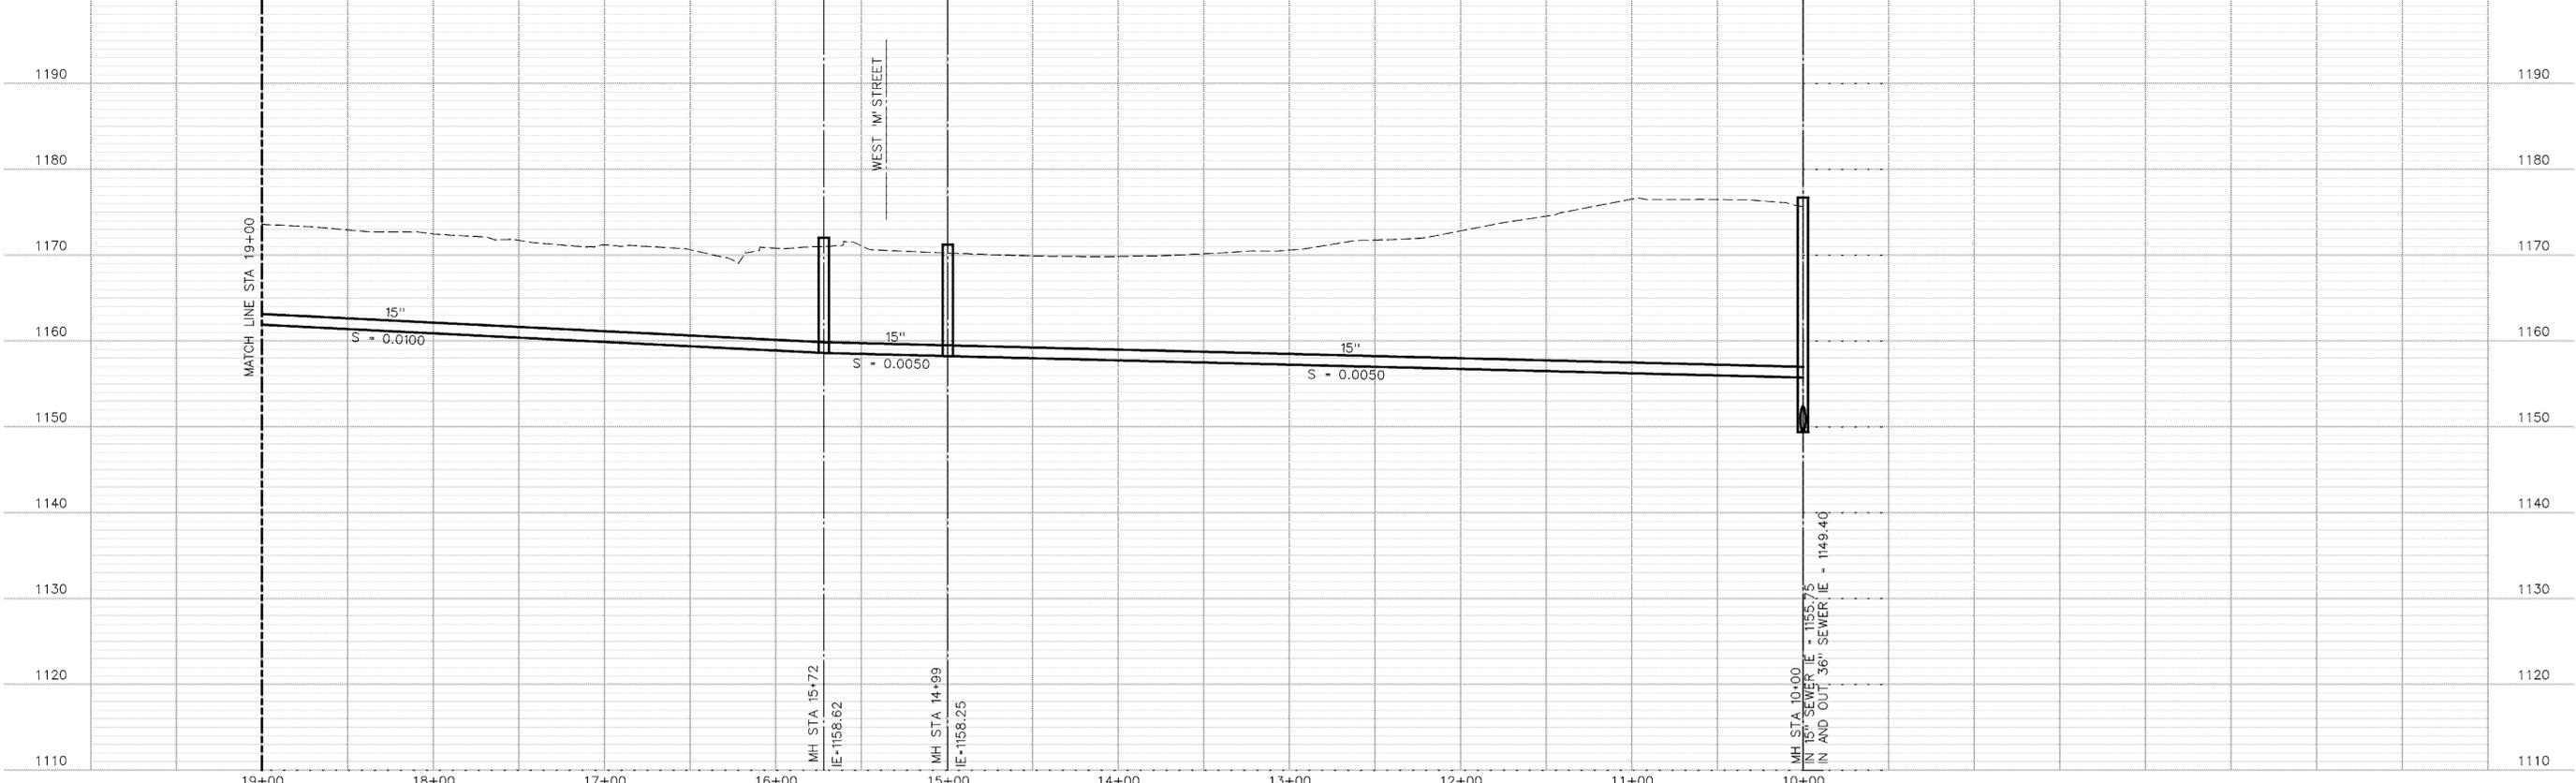

ISSUE	DATE	DESCRIPTION
01	10-27-04	30% REVIEW DOCUMENTS

PROJECT MANAGER	KENT PRIOR
CIVIL	SCOTT AURIT
STRUCTURAL	
ARCHITECTURAL	
PROCESS	
MECHANICAL	
ELECTRICAL	
INSTRUMENTATION	
PROJECT NUMBER	12733

PRELIMINARY
NOT FOR
CONSTRUCTION
OR
RECORDING



**West 'O' Street
Trunk Sewer Extension
Lincoln, Nebraska
2005**


**SEGMENT 1
PLAN AND PROFILE
STA 10+00 TO STA 19+00**

0 1" 2"	FILENAME O0G013.DGN	SHEET
	SCALE AS SHOWN	G013


C:\WINDM\LINCOLN\O_STTRUNK_SEWER\00G013.DGN
10/26/2004 9:10:33 AM JRay

C:\WINDOWS\LINCOLN\O_STTRUNK_SEWER\006015.DGN
10/26/2004 9:11:15 AM JRay

INTERSTATE 80

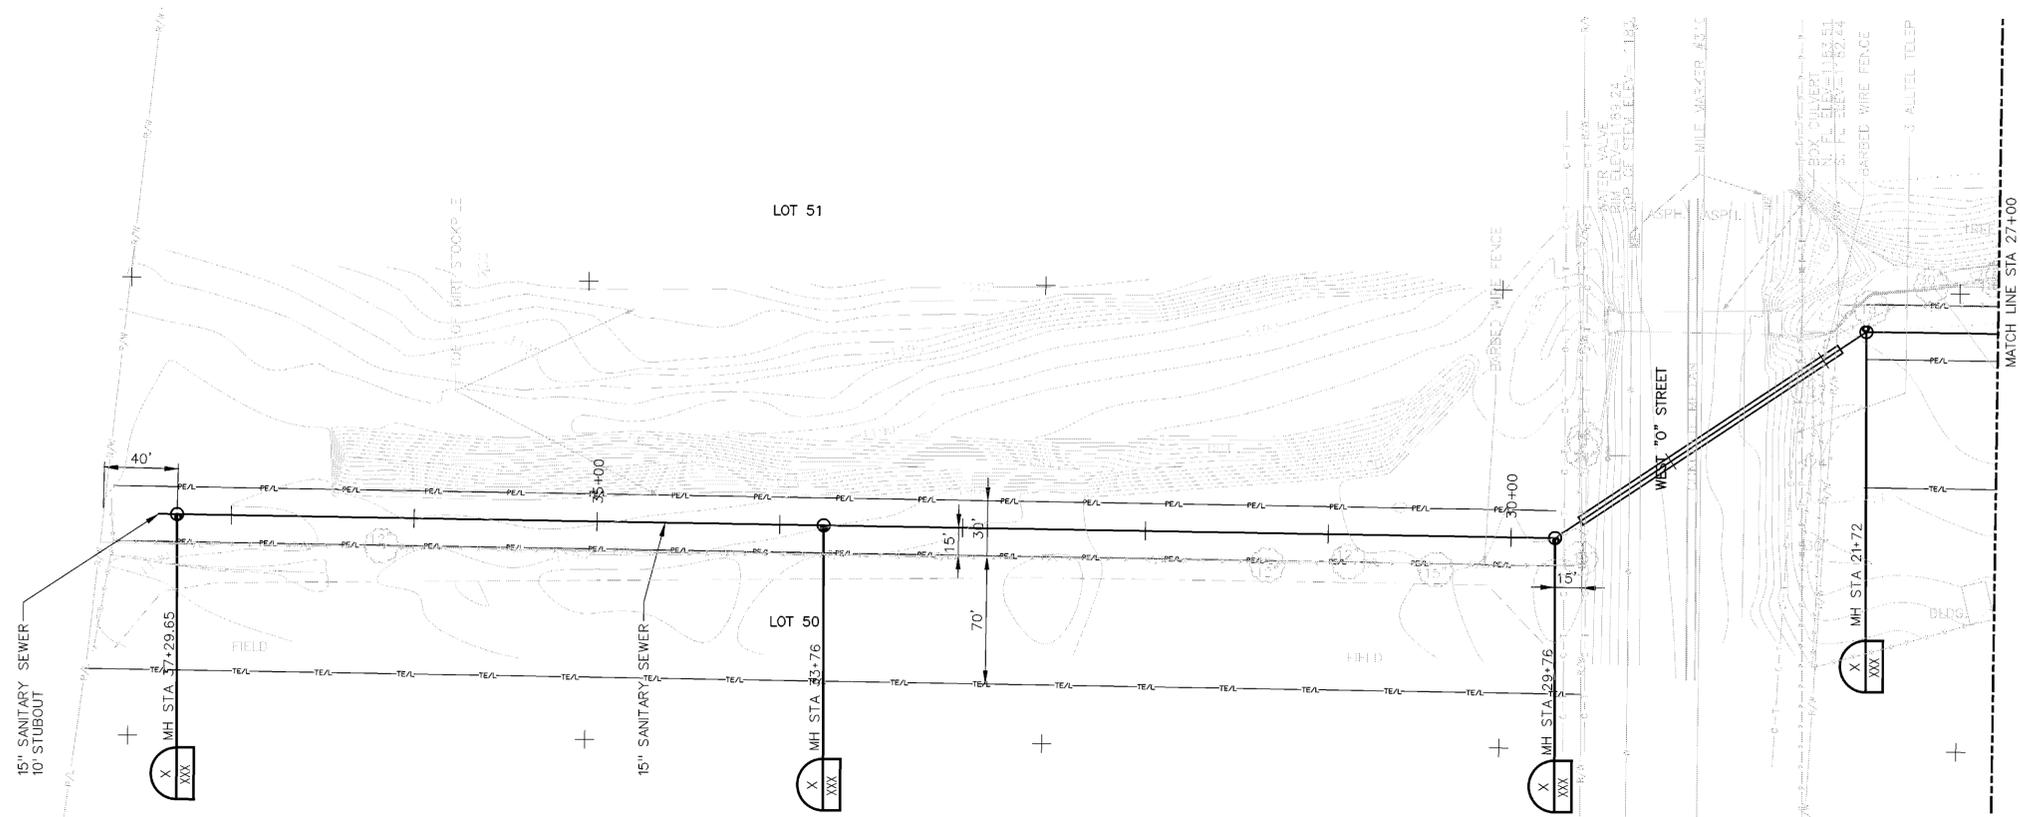

HORIZONTAL SCALE: 1"=50'
VERTICAL SCALE: 1"=10'
CONTOUR INTERVAL: 1'-0"

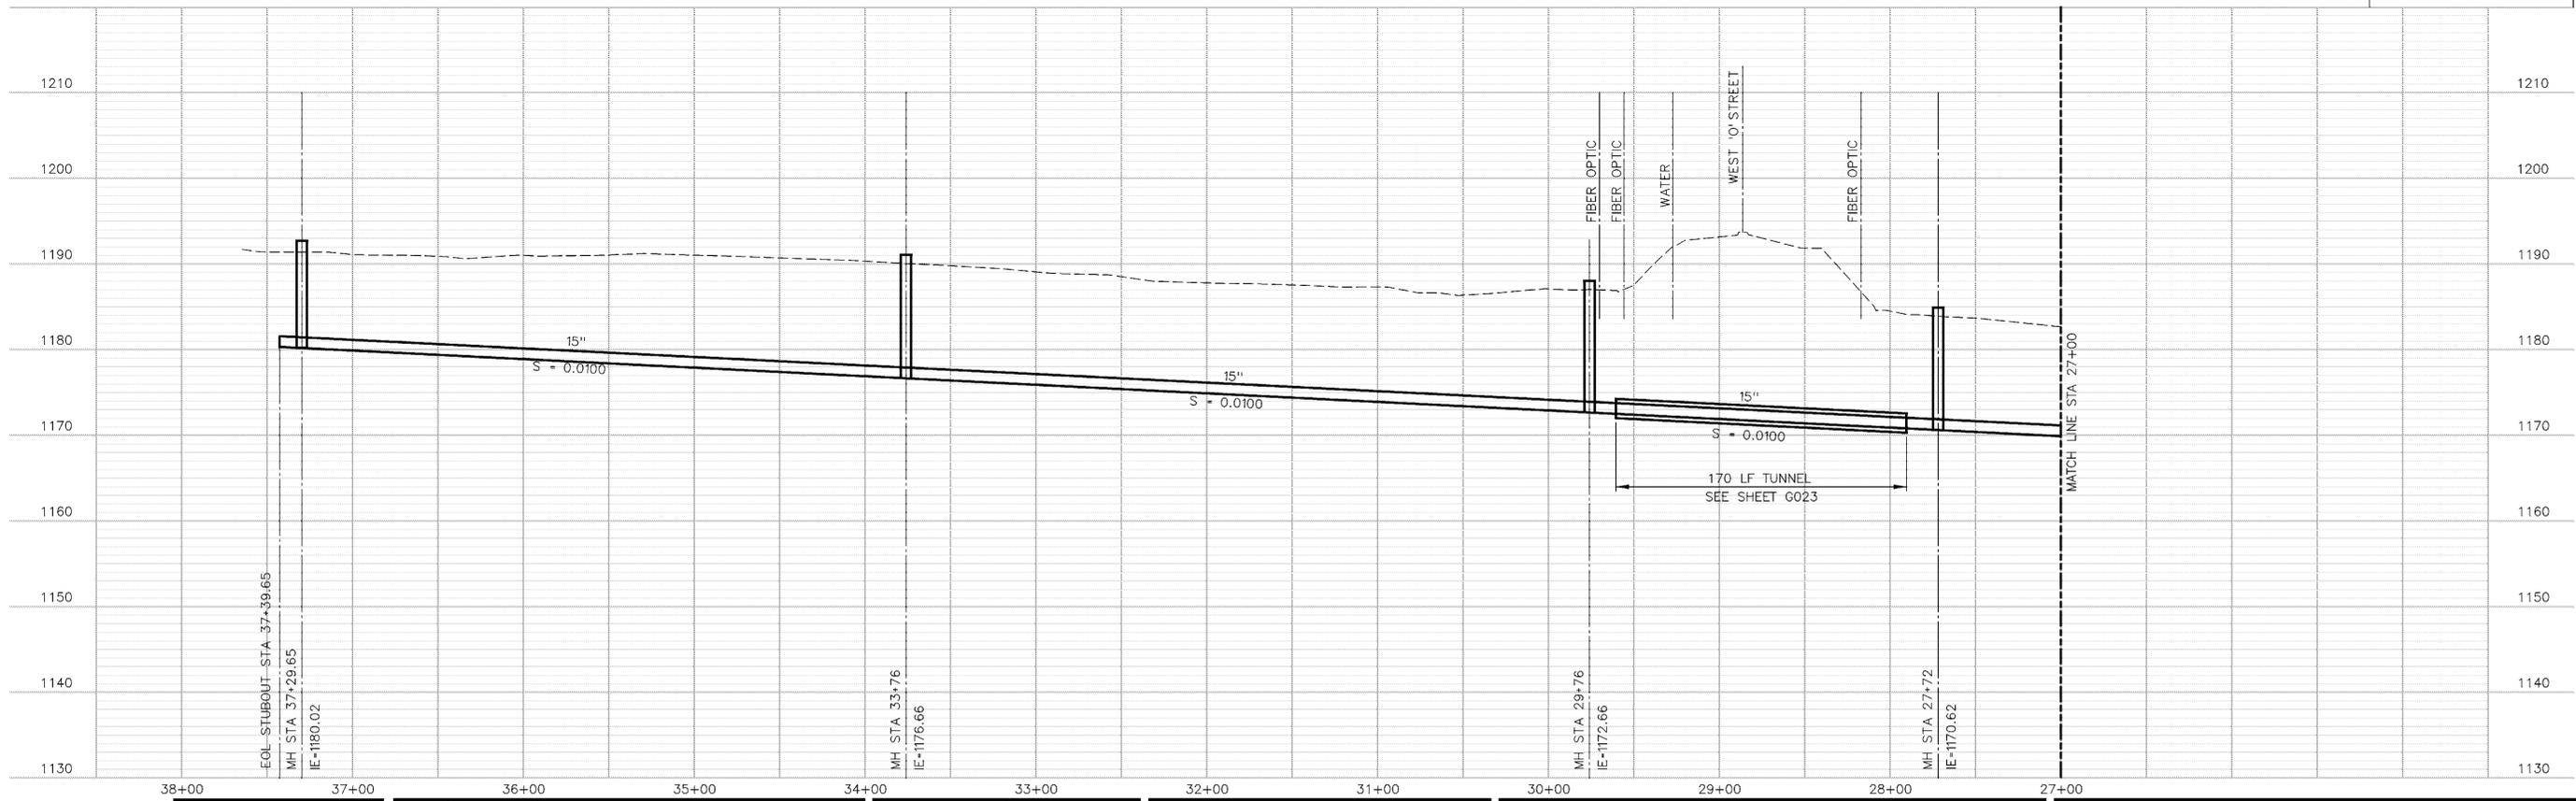

ISSUE	DATE	DESCRIPTION
01	10-27-04	30% REVIEW DOCUMENTS

PROJECT MANAGER	KENT PRIOR
CIVIL	SCOTT AURIT
STRUCTURAL	
ARCHITECTURAL	
PROCESS	
MECHANICAL	
ELECTRICAL	
INSTRUMENTATION	
PROJECT NUMBER	12733


PRELIMINARY
NOT FOR
CONSTRUCTION
OR
RECORDING




**West 'O' Street
Trunk Sewer Extension
Lincoln, Nebraska
2005**

SEGMENT 1 PLAN AND PROFILE STA 27+00 TO STA 37+29.65		
		FILENAME 00G015.DGN SCALE AS SHOWN
		SHEET G015

C:\WINDOWS\LINCOLN\O_STTRUNK_SEWER\006016.DGN
10/26/2004 9:11:40 AM JRaye

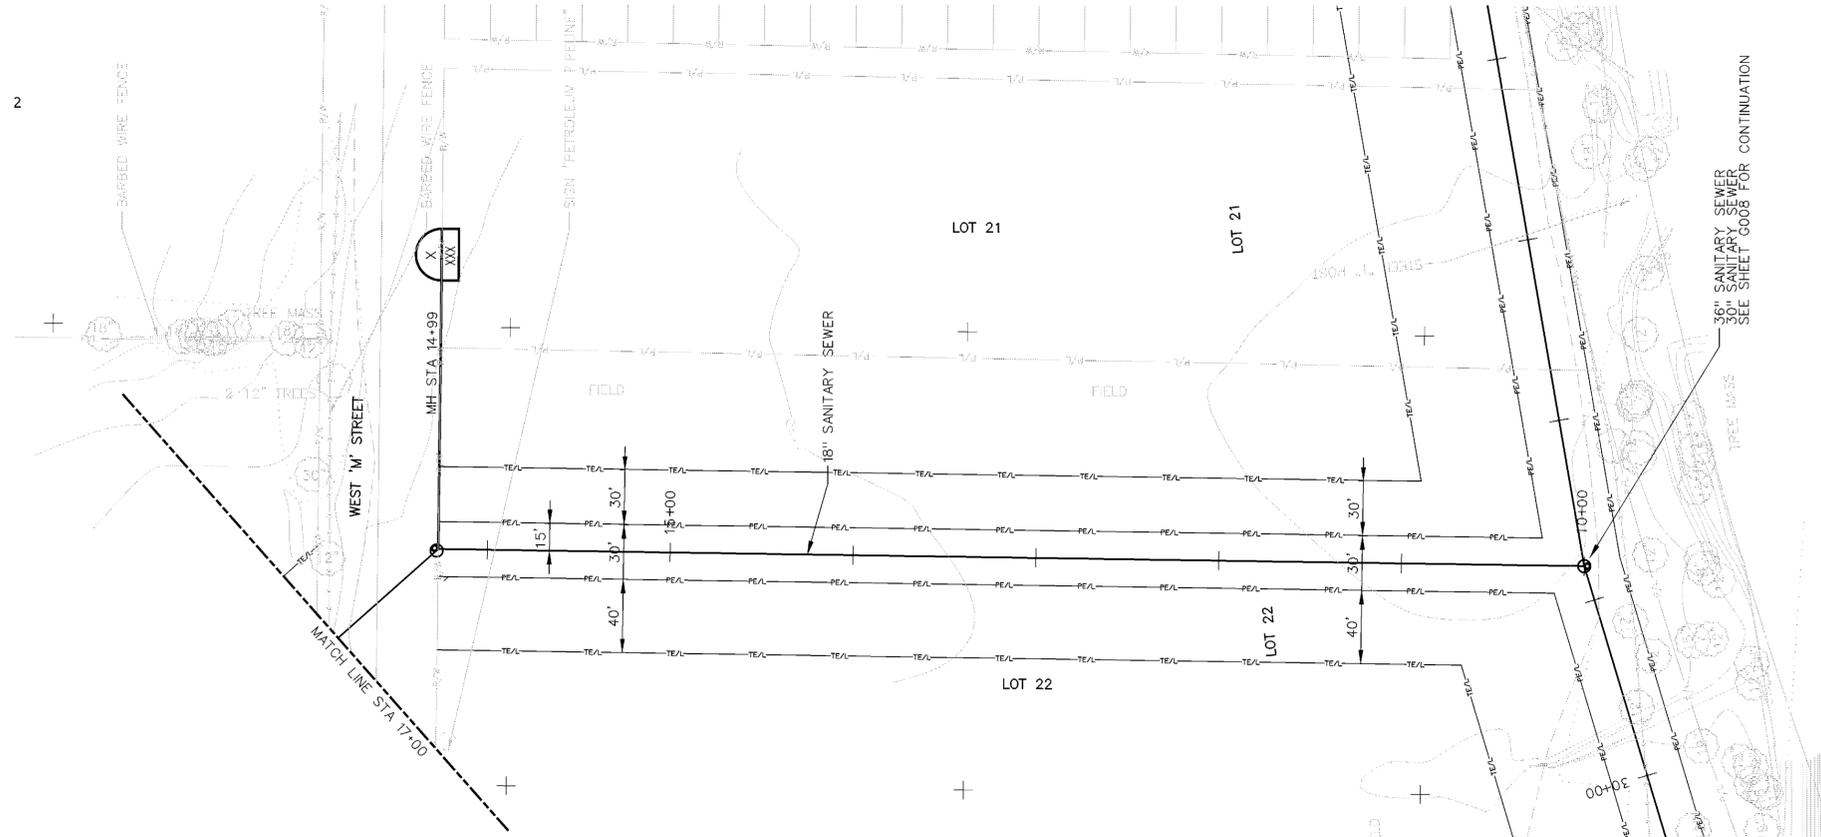

HORIZONTAL SCALE: 1"=50'
VERTICAL SCALE: 1"=10'
CONTOUR INTERVAL: 1'-0"

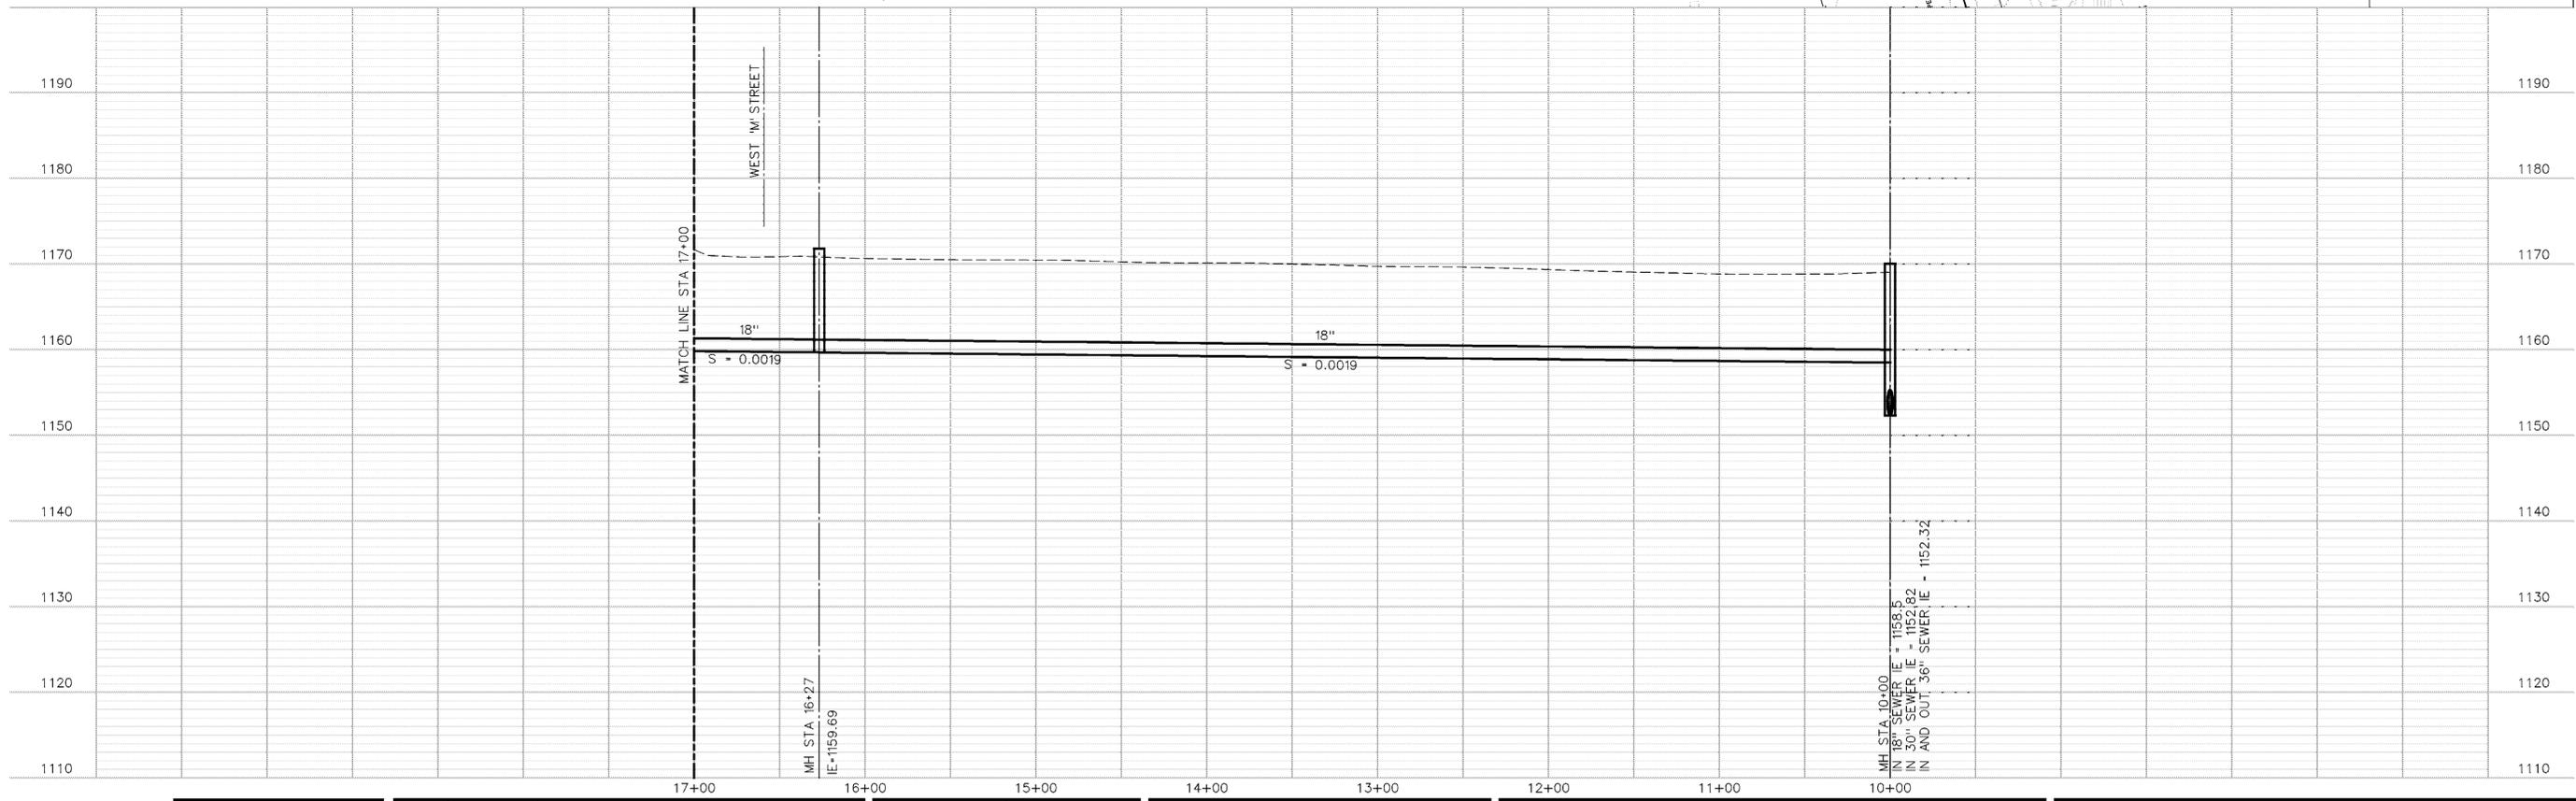

ISSUE	DATE	DESCRIPTION
01	10-27-04	30% REVIEW DOCUMENTS

PROJECT MANAGER	KENT PRIOR
CIVIL	SCOTT AURIT
STRUCTURAL	
ARCHITECTURAL	
PROCESS	
MECHANICAL	
ELECTRICAL	
INSTRUMENTATION	
PROJECT NUMBER	12733


PRELIMINARY
NOT FOR
CONSTRUCTION
OR
RECORDING




**West 'O' Street
Trunk Sewer Extension
Lincoln, Nebraska
2005**

**SEGMENT 3
PLAN AND PROFILE
STA 10+00 TO STA 17+00**

	FILENAME: 00G016.DGN SCALE: AS SHOWN	SHEET G016
--	---	----------------------

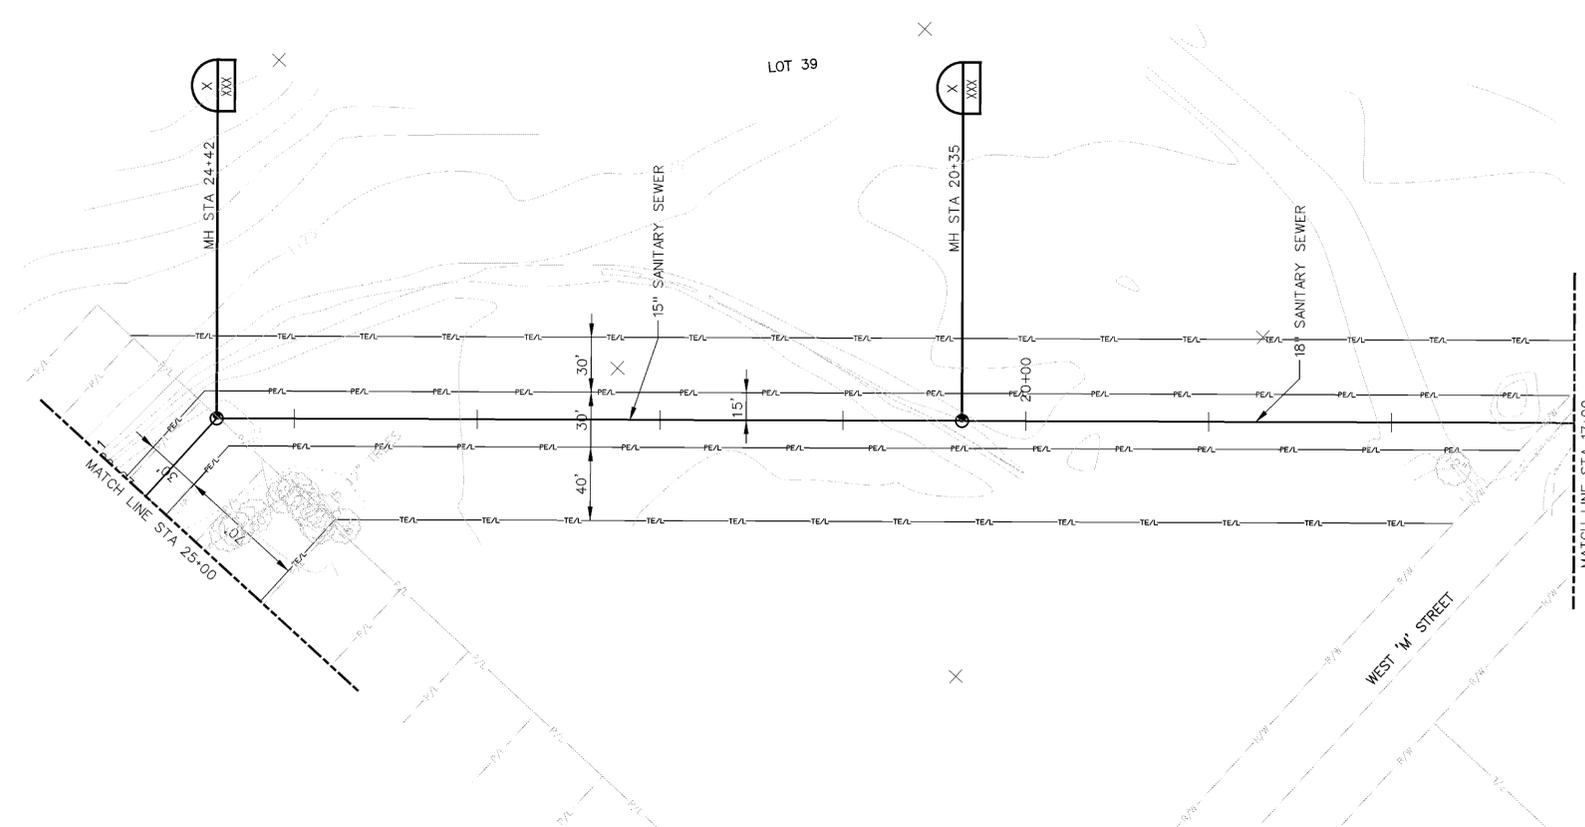

HORIZONTAL SCALE: 1"=50'
 VERTICAL SCALE: 1"=10'
 CONTOUR INTERVAL: 1'-0"

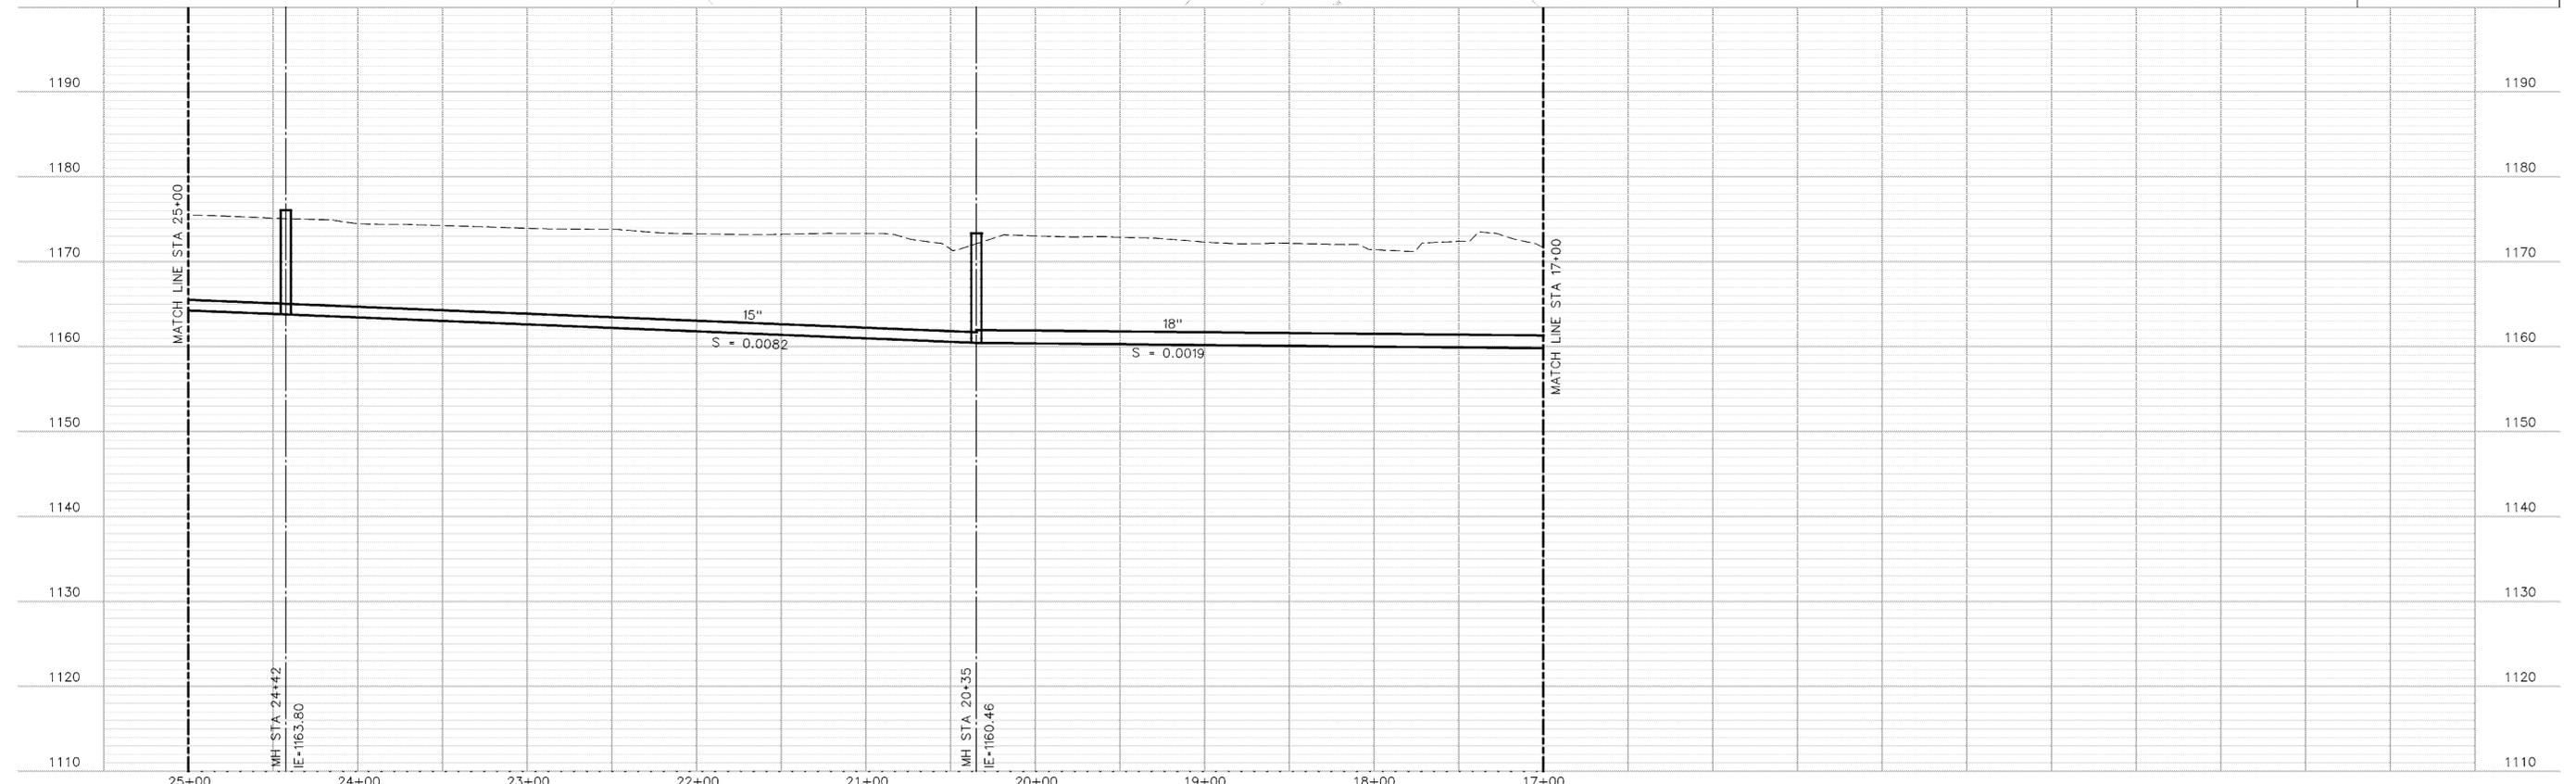

C:\WINDOWS\LINCOLN\O_STTRUNK_SEWER\006017.DGN
 10/26/2004 9:12:03 AM JRayner



ISSUE	DATE	DESCRIPTION
01	10-27-04	30% REVIEW DOCUMENTS


PROJECT MANAGER	KENT PRIOR
CIVIL	SCOTT AURIT
STRUCTURAL	
ARCHITECTURAL	
PROCESS	
MECHANICAL	
ELECTRICAL	
INSTRUMENTATION	
PROJECT NUMBER	12733

PRELIMINARY
 NOT FOR
 CONSTRUCTION
 OR
 RECORDING




**West 'O' Street
 Trunk Sewer Extension
 Lincoln, Nebraska
 2005**

SEGMENT 3 PLAN AND PROFILE STA 17+00 TO STA 25+00		SHEET G017
	FILENAME: 00G017.DGN SCALE: AS SHOWN	

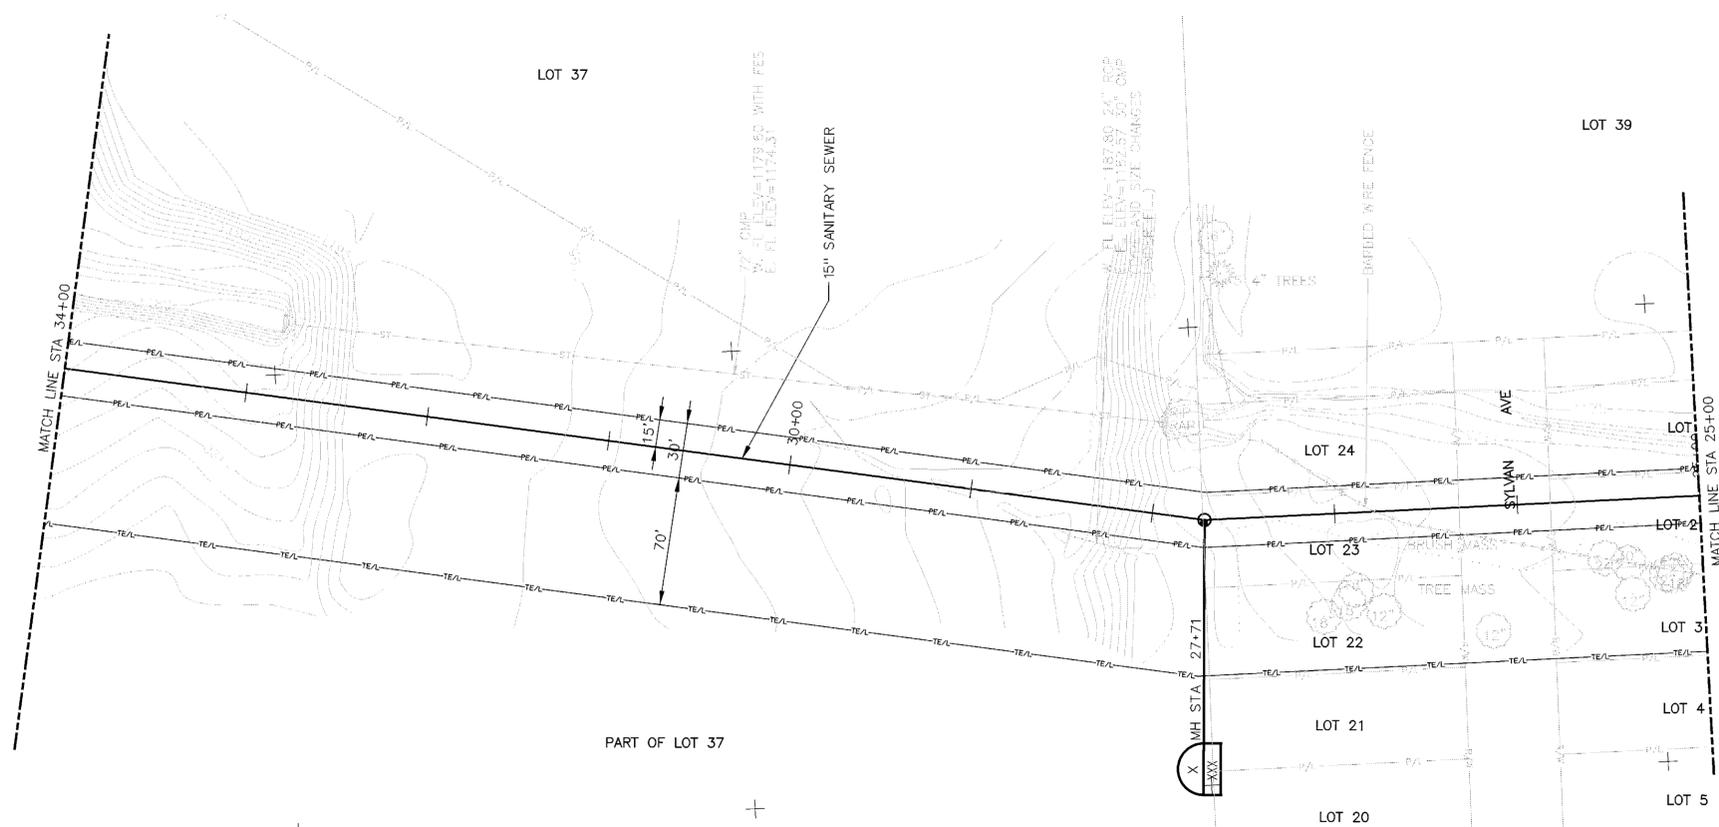

HORIZONTAL SCALE: 1"=50'
 VERTICAL SCALE: 1"=10'
 CONTOUR INTERVAL: 1'-0"

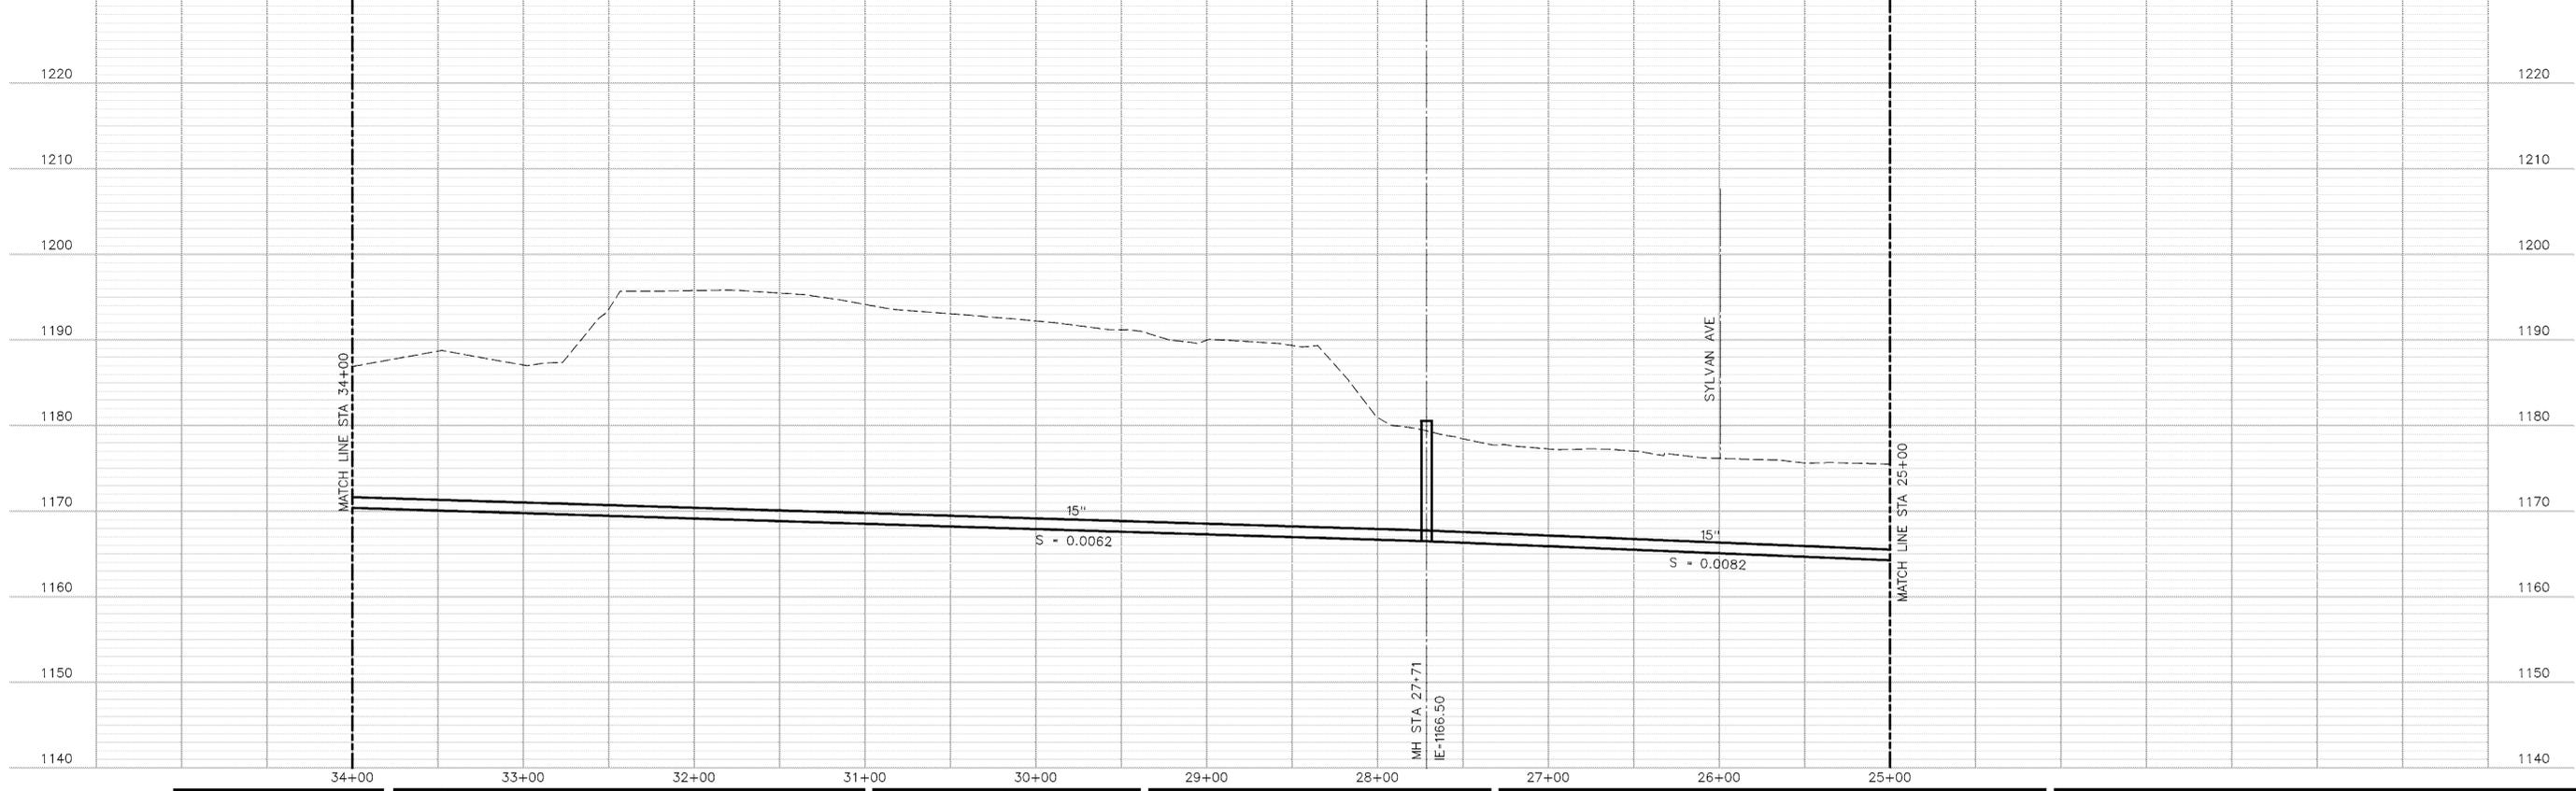

C:\WINDOWS\LINCOLN_O_STTRUNK_SEWER\006018.DGN
 10/26/2004 9:12:24 AM JRayner



ISSUE	DATE	DESCRIPTION
01	10-27-04	30% REVIEW DOCUMENTS

PROJECT MANAGER	KENT PRIOR
CIVIL	SCOTT AURIT
STRUCTURAL	
ARCHITECTURAL	
PROCESS	
MECHANICAL	
ELECTRICAL	
INSTRUMENTATION	
PROJECT NUMBER	12733


PRELIMINARY
 NOT FOR
 CONSTRUCTION
 OR
 RECORDING




**West 'O' Street
 Trunk Sewer Extension
 Lincoln, Nebraska
 2005**

**SEGMENT 3
 PLAN AND PROFILE
 STA 25+00 TO STA 34+00**

	FILENAME 00G018.DGN SCALE AS SHOWN	SHEET G018
--	---------------------------------------	----------------------

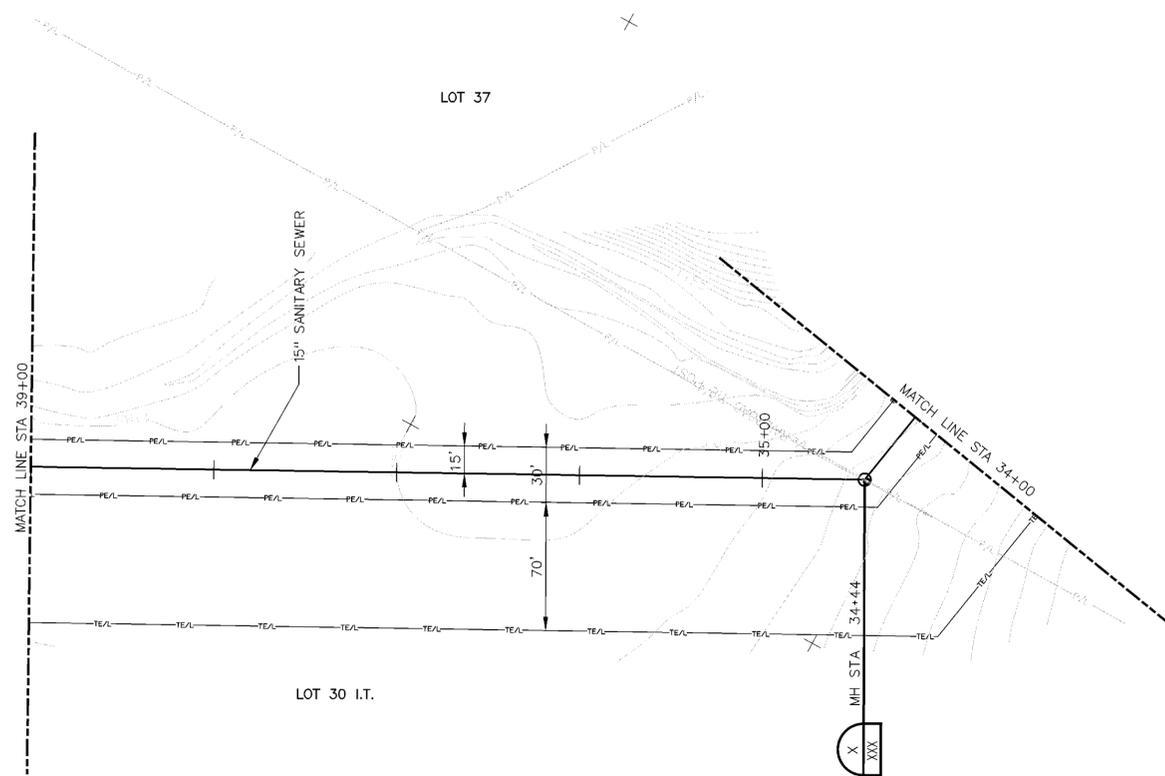

HORIZONTAL SCALE: 1"=50'
 VERTICAL SCALE: 1"=10'
 CONTOUR INTERVAL: 1'-0"

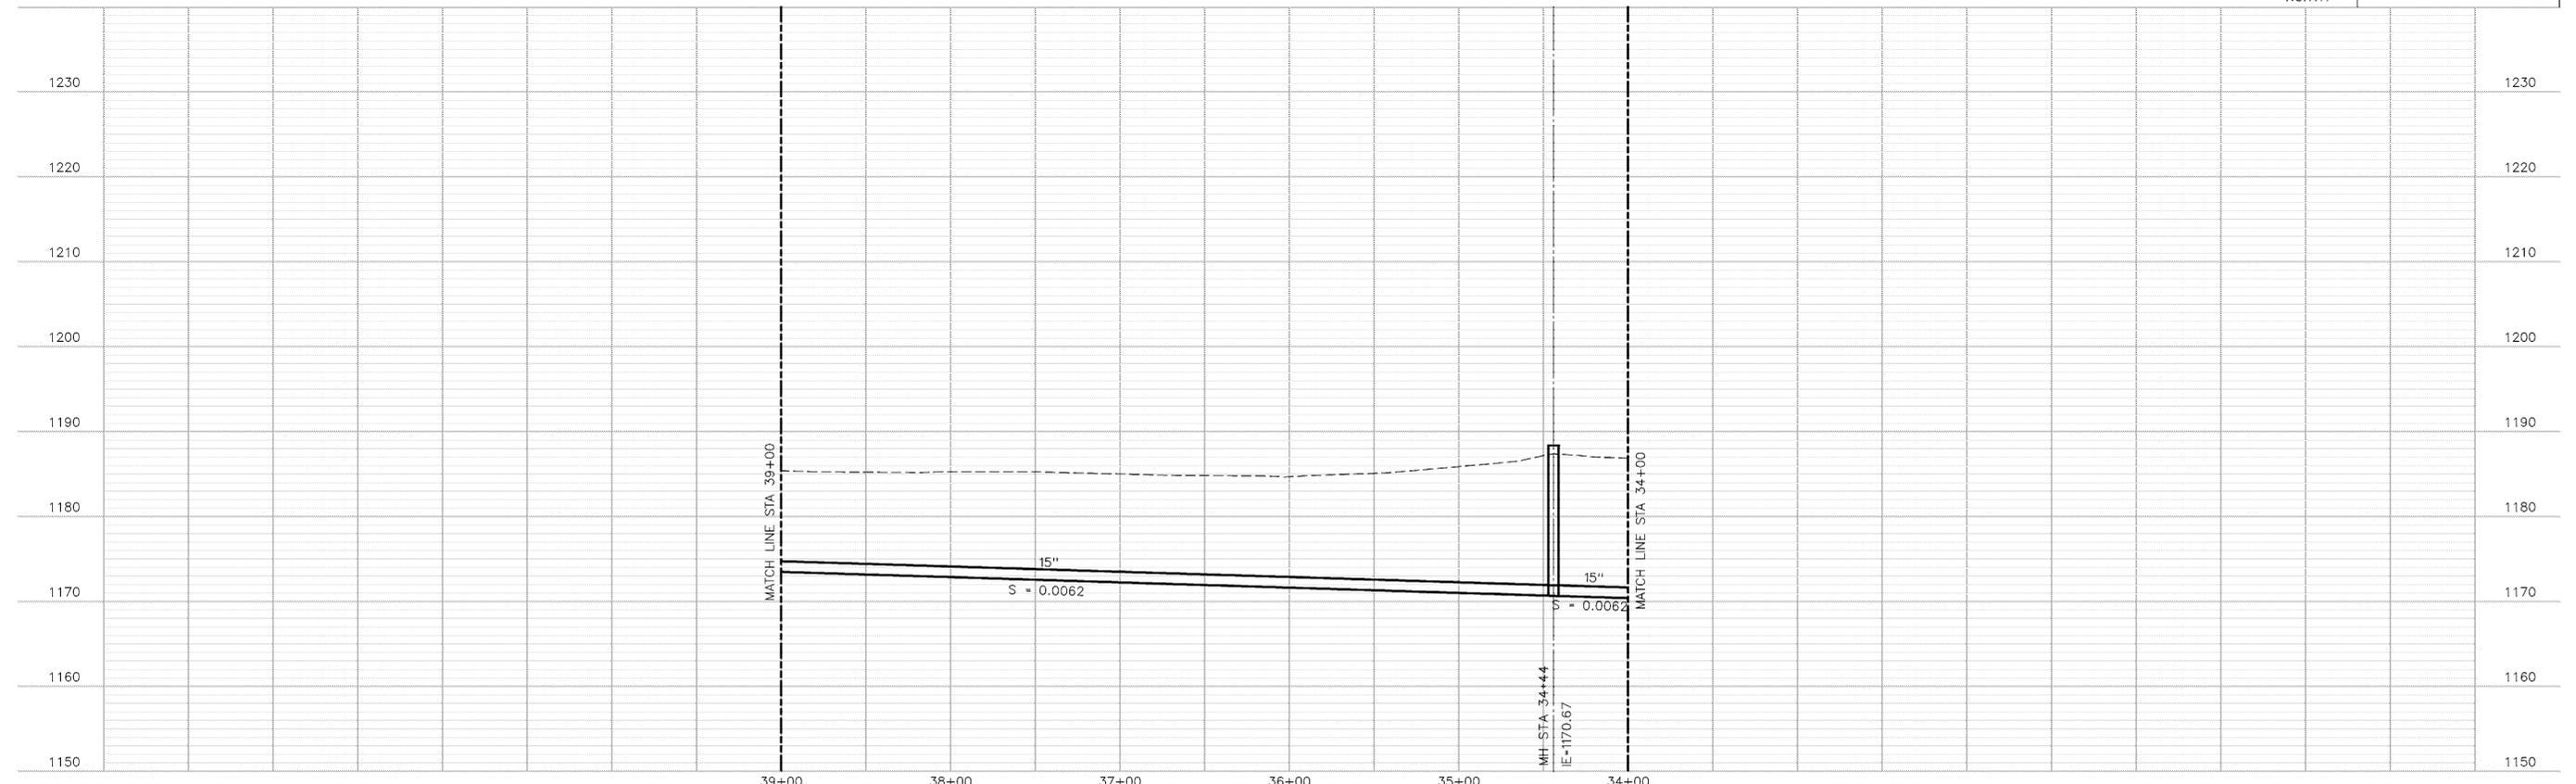


C:\WINDOWS\LINCOLN\O_STTRUNK_SEWER\006019.DGN 10/26/2004 9:12:43 AM JRayner



ISSUE	DATE	DESCRIPTION
01	10-27-04	30% REVIEW DOCUMENTS


PROJECT MANAGER	KENT PRIOR
CIVIL	SCOTT AURIT
STRUCTURAL	
ARCHITECTURAL	
PROCESS	
MECHANICAL	
ELECTRICAL	
INSTRUMENTATION	
PROJECT NUMBER	12733

PRELIMINARY
 NOT FOR
 CONSTRUCTION
 OR
 RECORDING

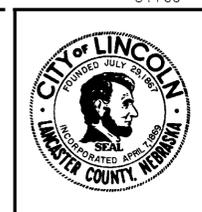


**West 'O' Street
 Trunk Sewer Extension
 Lincoln, Nebraska
 2005**

SEGMENT 3 PLAN AND PROFILE STA 34+00 TO STA 39+00		 FILENAME 00G019.DGN SCALE AS SHOWN	SHEET G019

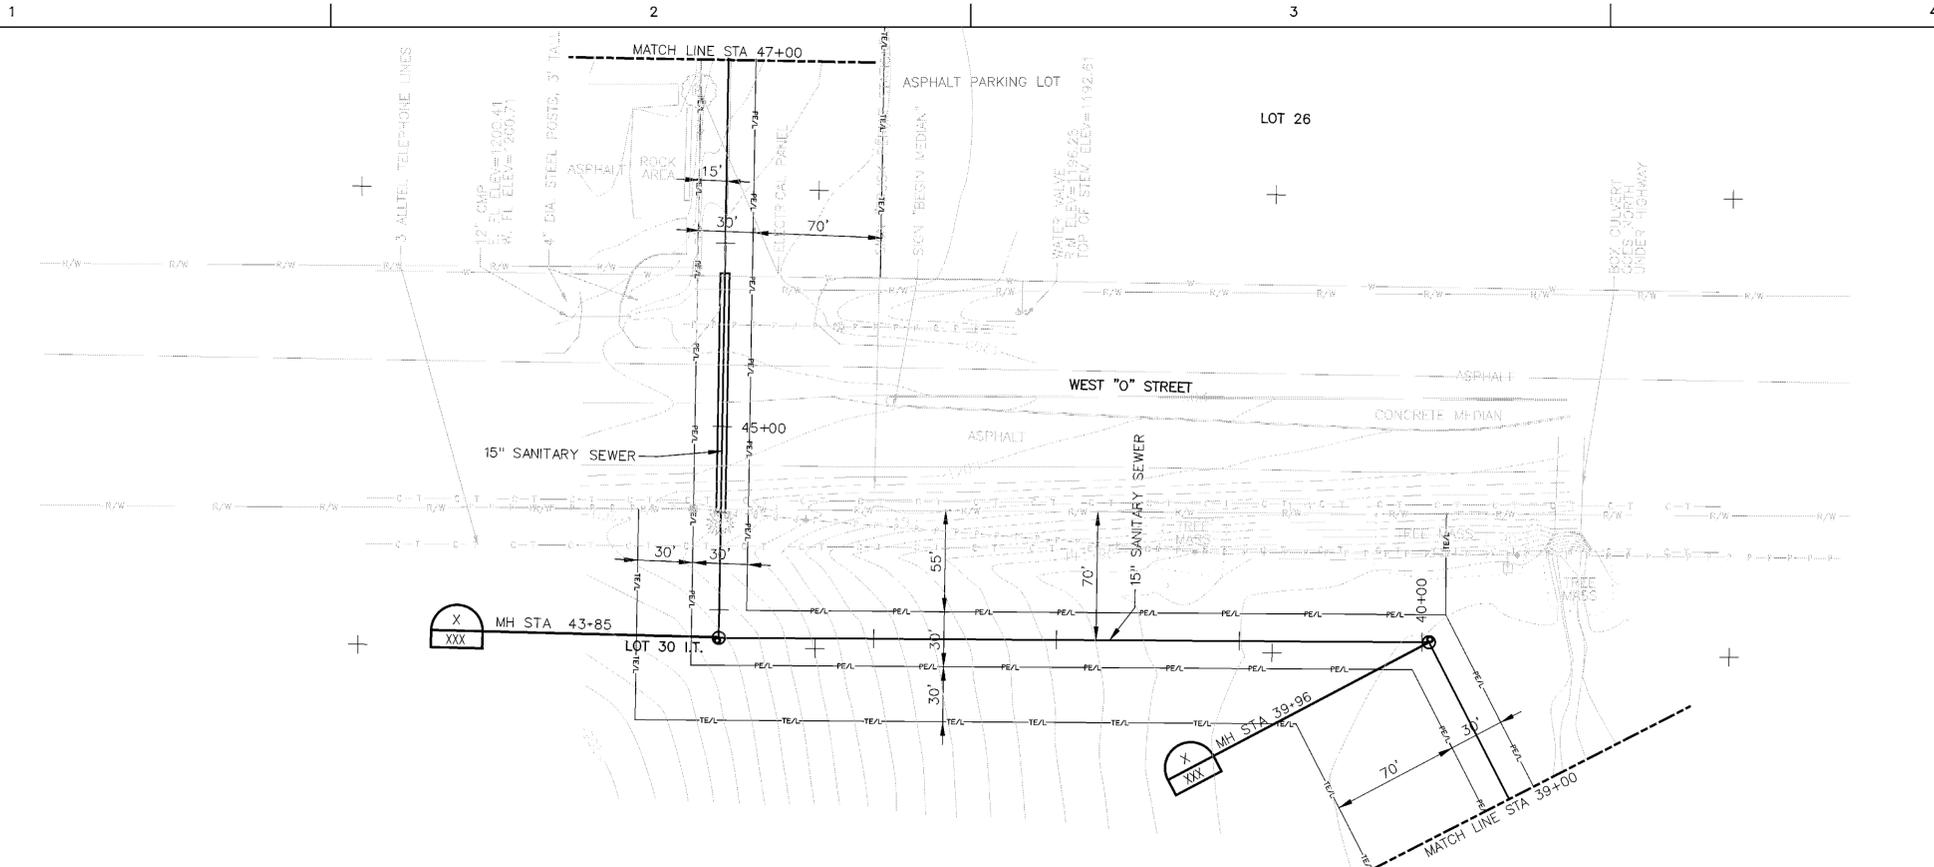

HORIZONTAL SCALE: 1"=50'
 VERTICAL SCALE: 1"=10'
 CONTOUR INTERVAL: 1'-0"

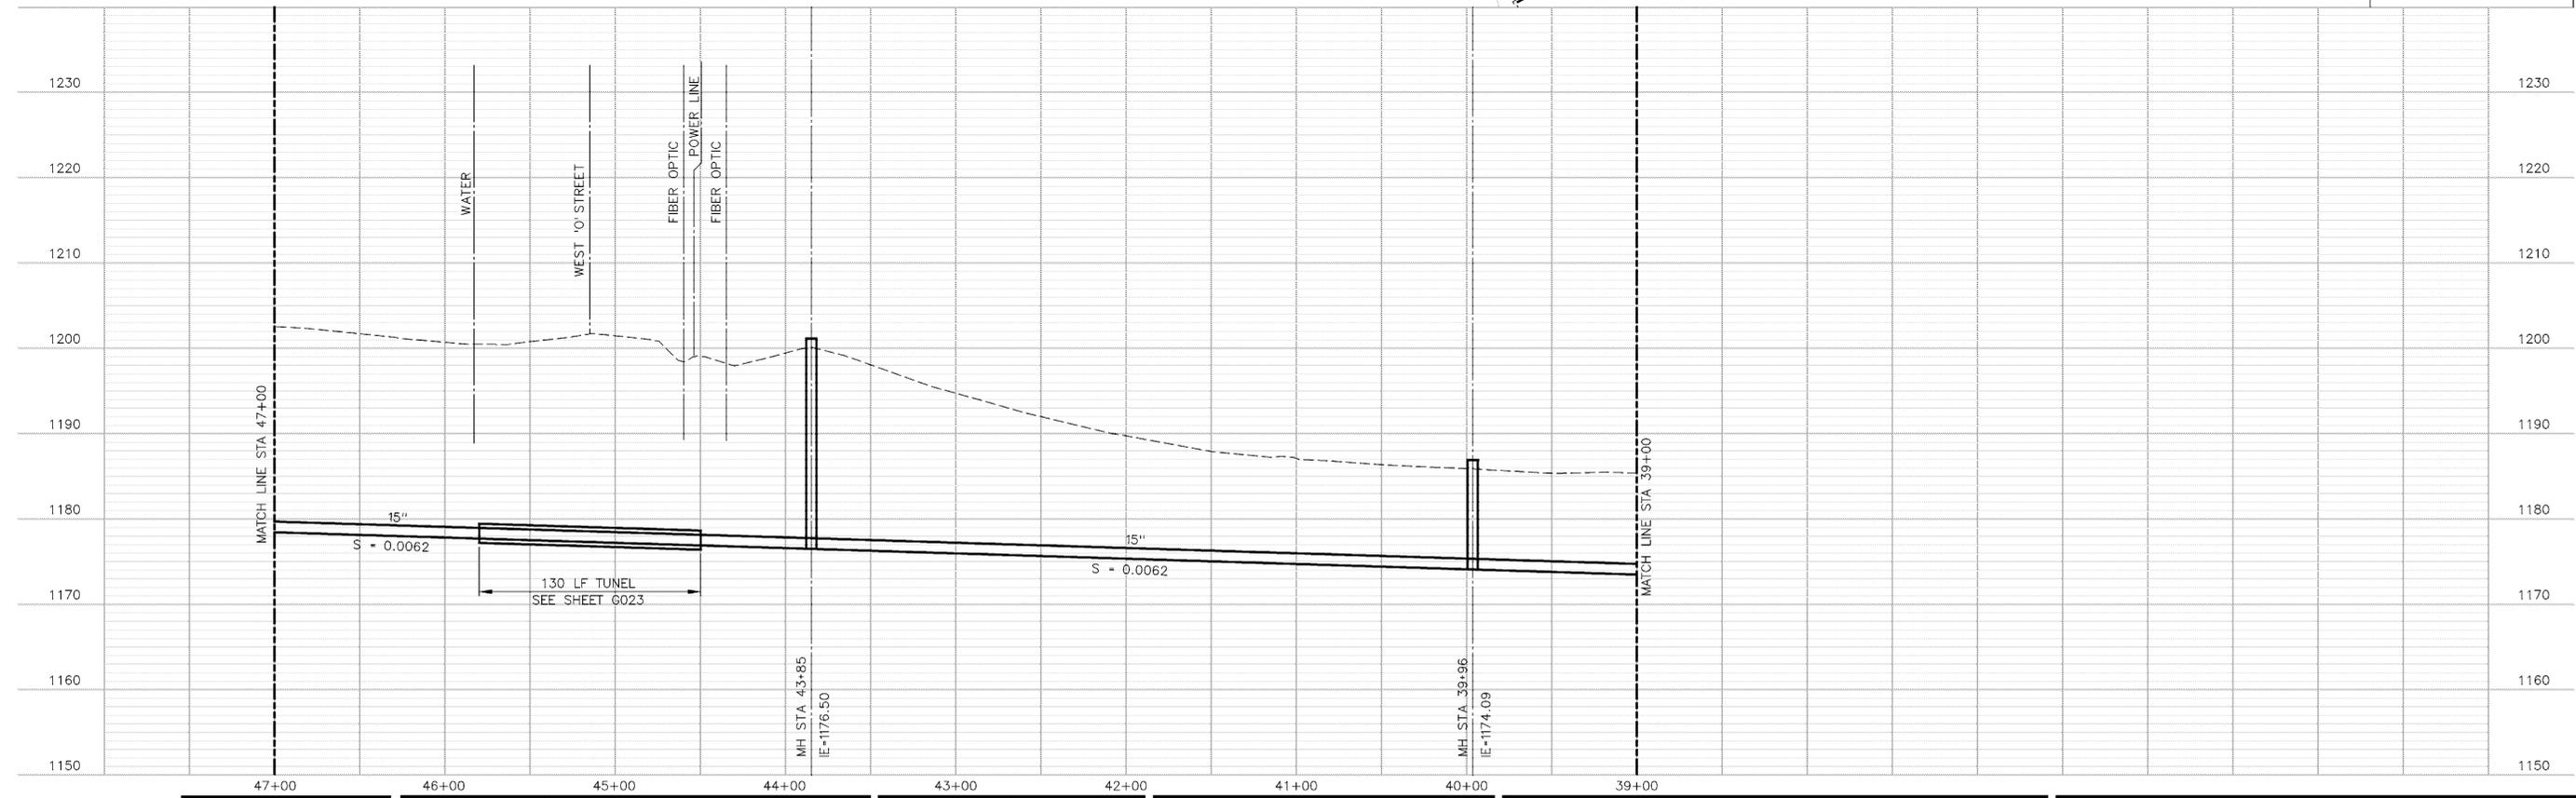

C:\WINDOWS\LINCOLN_O_STRUNK_SEWER\006020.DGN 10/26/2004 9:13:04 AM JRayner



ISSUE	DATE	DESCRIPTION
01	10-27-04	30% REVIEW DOCUMENTS

PROJECT MANAGER	KENT PRIOR
CIVIL	SCOTT AURIT
STRUCTURAL	
ARCHITECTURAL	
PROCESS	
MECHANICAL	
ELECTRICAL	
INSTRUMENTATION	
PROJECT NUMBER	12733


PRELIMINARY
 NOT FOR
 CONSTRUCTION
 OR
 RECORDING




**West 'O' Street
 Trunk Sewer Extension
 Lincoln, Nebraska
 2005**

SEGMENT 3 PLAN AND PROFILE STA 39+00 TO STA 47+00		 FILENAME OOG020.DGN SCALE AS SHOWN	SHEET G020

C:\WINDOWS\LINCOLN\O_STTRUNK_SEWER\00G022.DGN
10/26/2004 9:13:51 AM J.Rayer

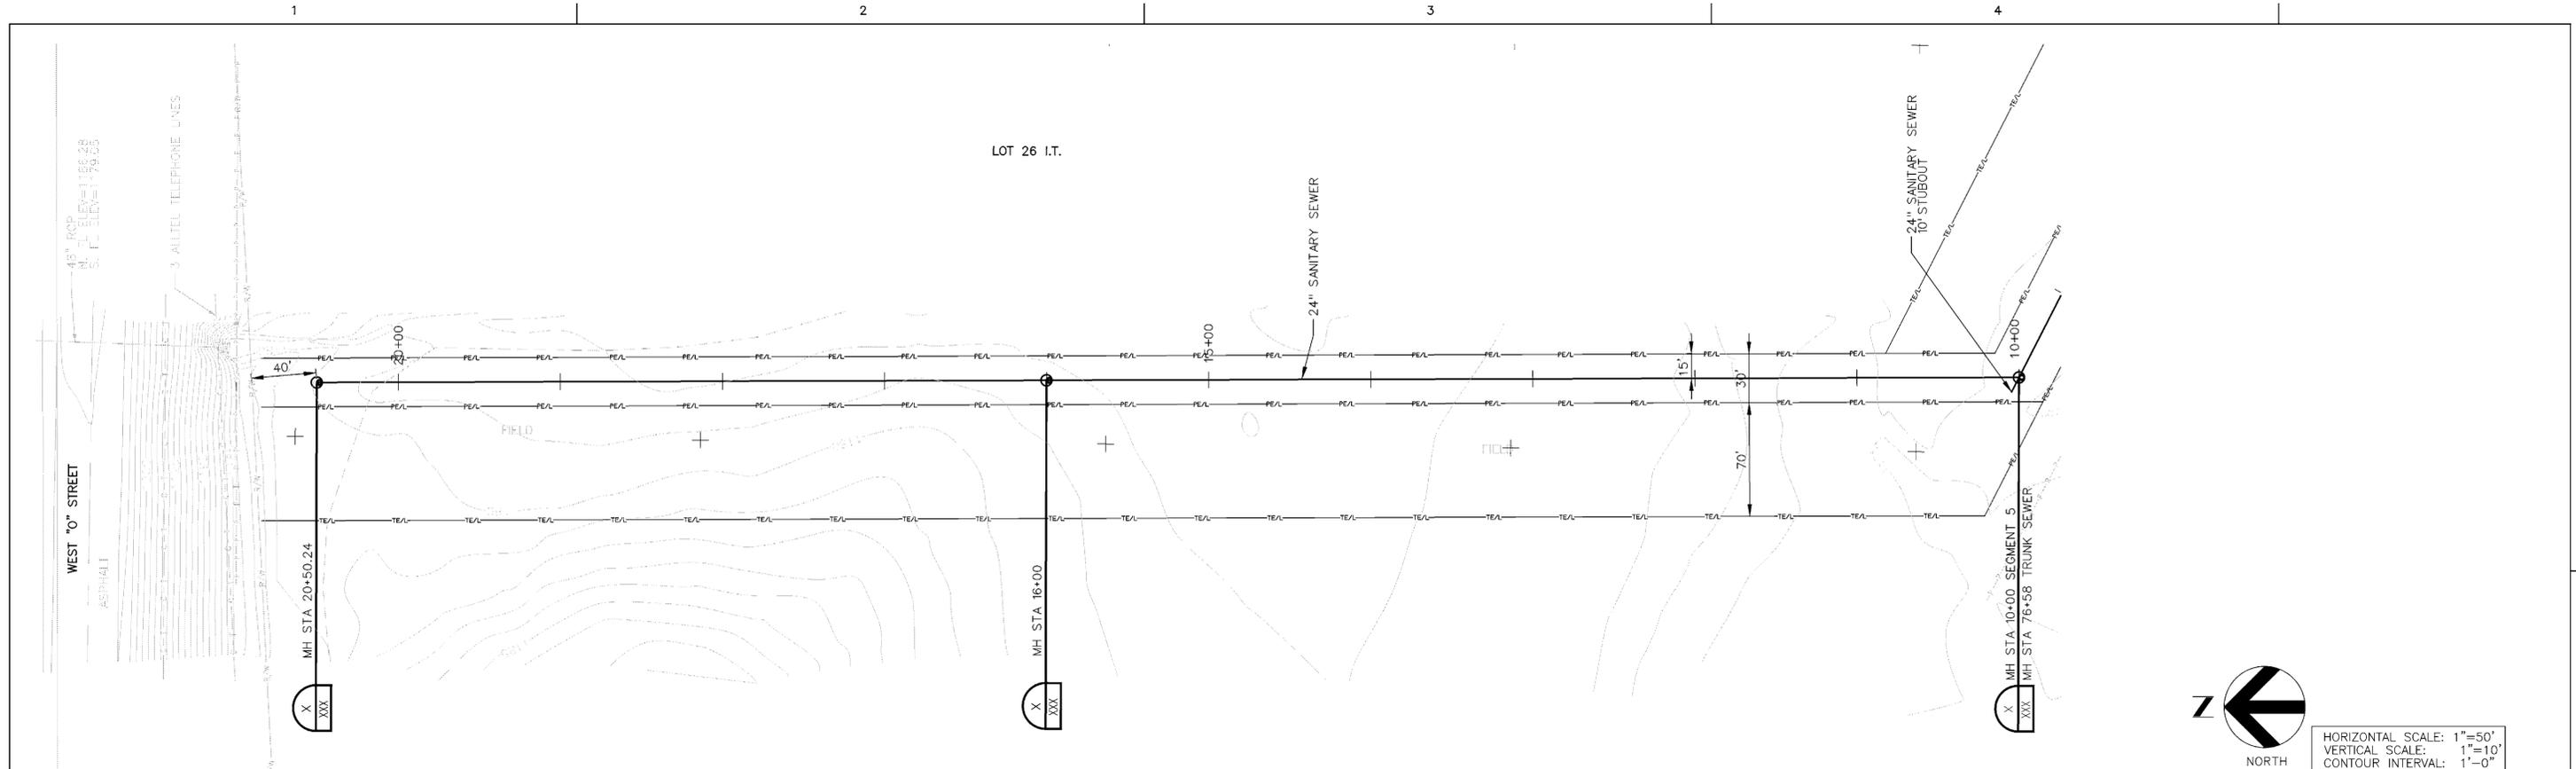

HORIZONTAL SCALE: 1"=50'
VERTICAL SCALE: 1"=10'
CONTOUR INTERVAL: 1'-0"

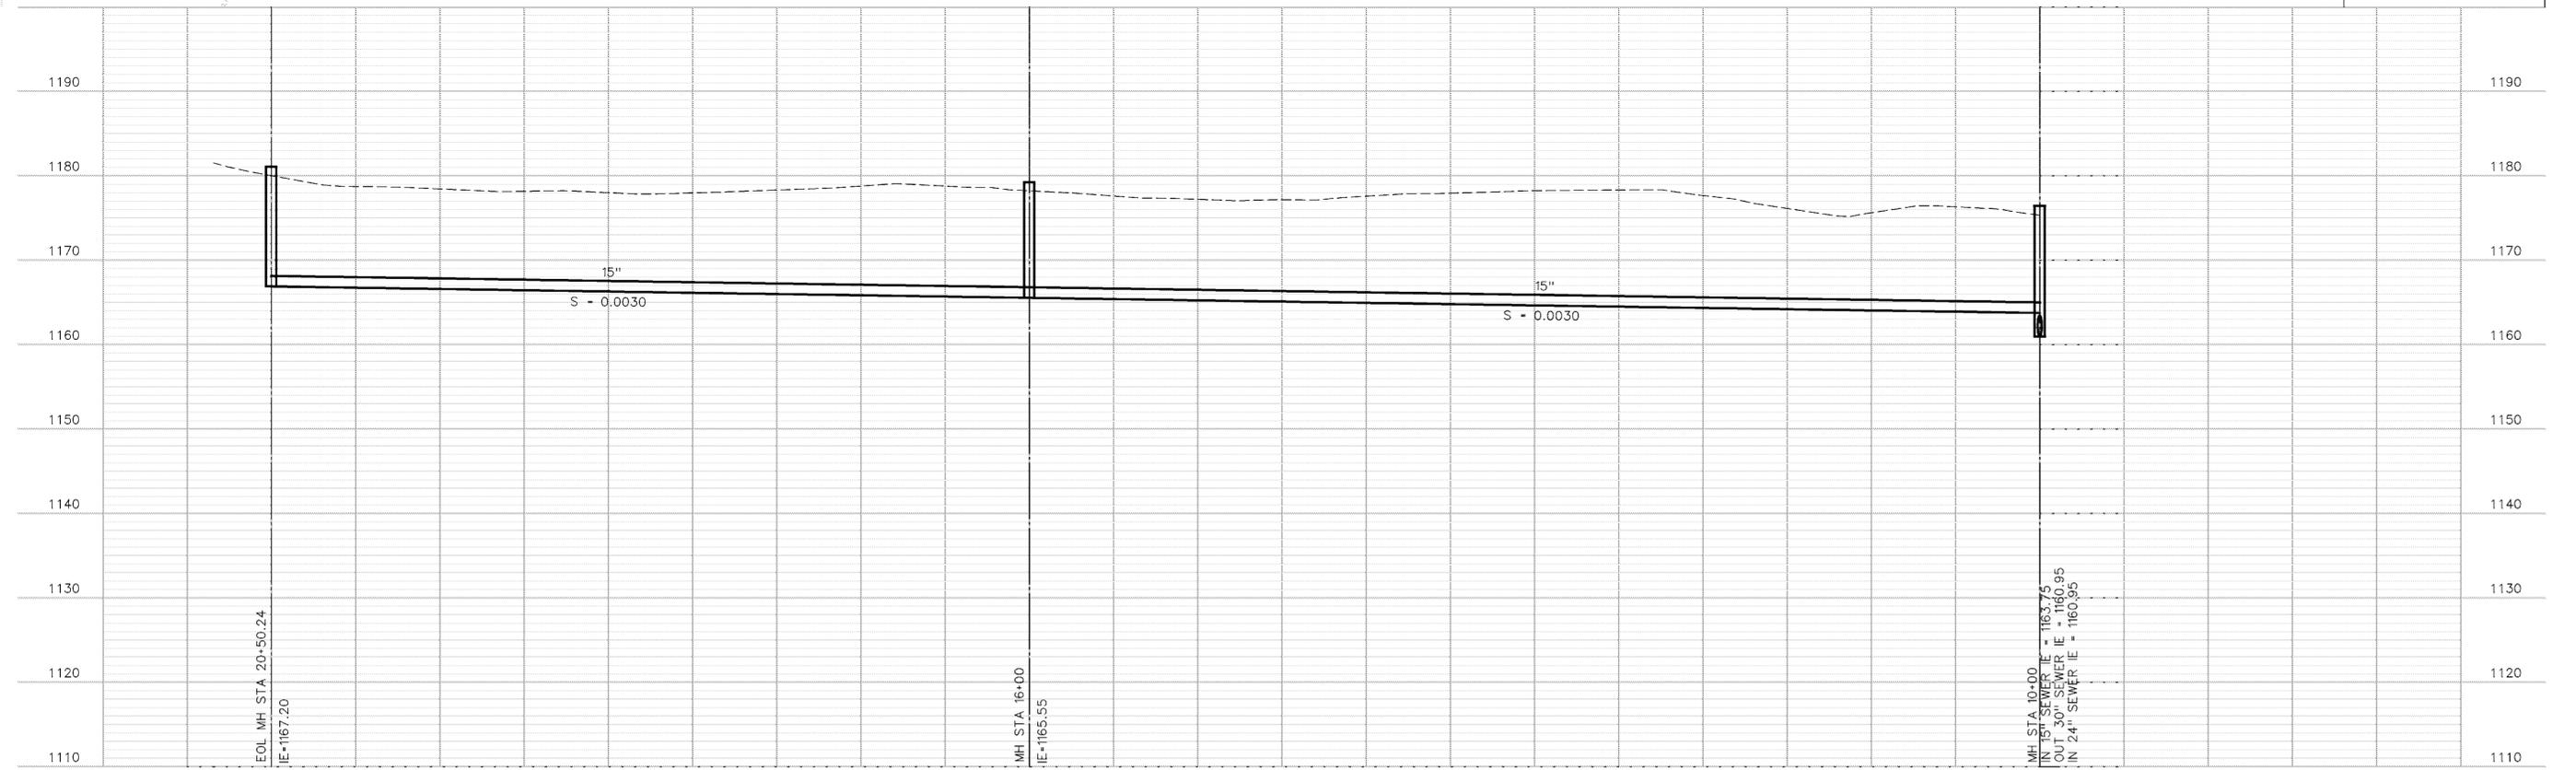

ISSUE	DATE	DESCRIPTION
01	10-27-04	30% REVIEW DOCUMENTS

PROJECT MANAGER	KENT PRIOR
CIVIL	SCOTT AURIT
STRUCTURAL	
ARCHITECTURAL	
PROCESS	
MECHANICAL	
ELECTRICAL	
INSTRUMENTATION	
PROJECT NUMBER	12733

PRELIMINARY
NOT FOR
CONSTRUCTION
OR
RECORDING



West 'O' Street
Trunk Sewer Extension
Lincoln, Nebraska
2005

**SEGMENT 5
PLAN AND PROFILE
STA 10+00 TO STA 20+50.24**

0 1" 2"	FILENAME: 00G022.DGN	SHEET
	SCALE: AS SHOWN	G022